




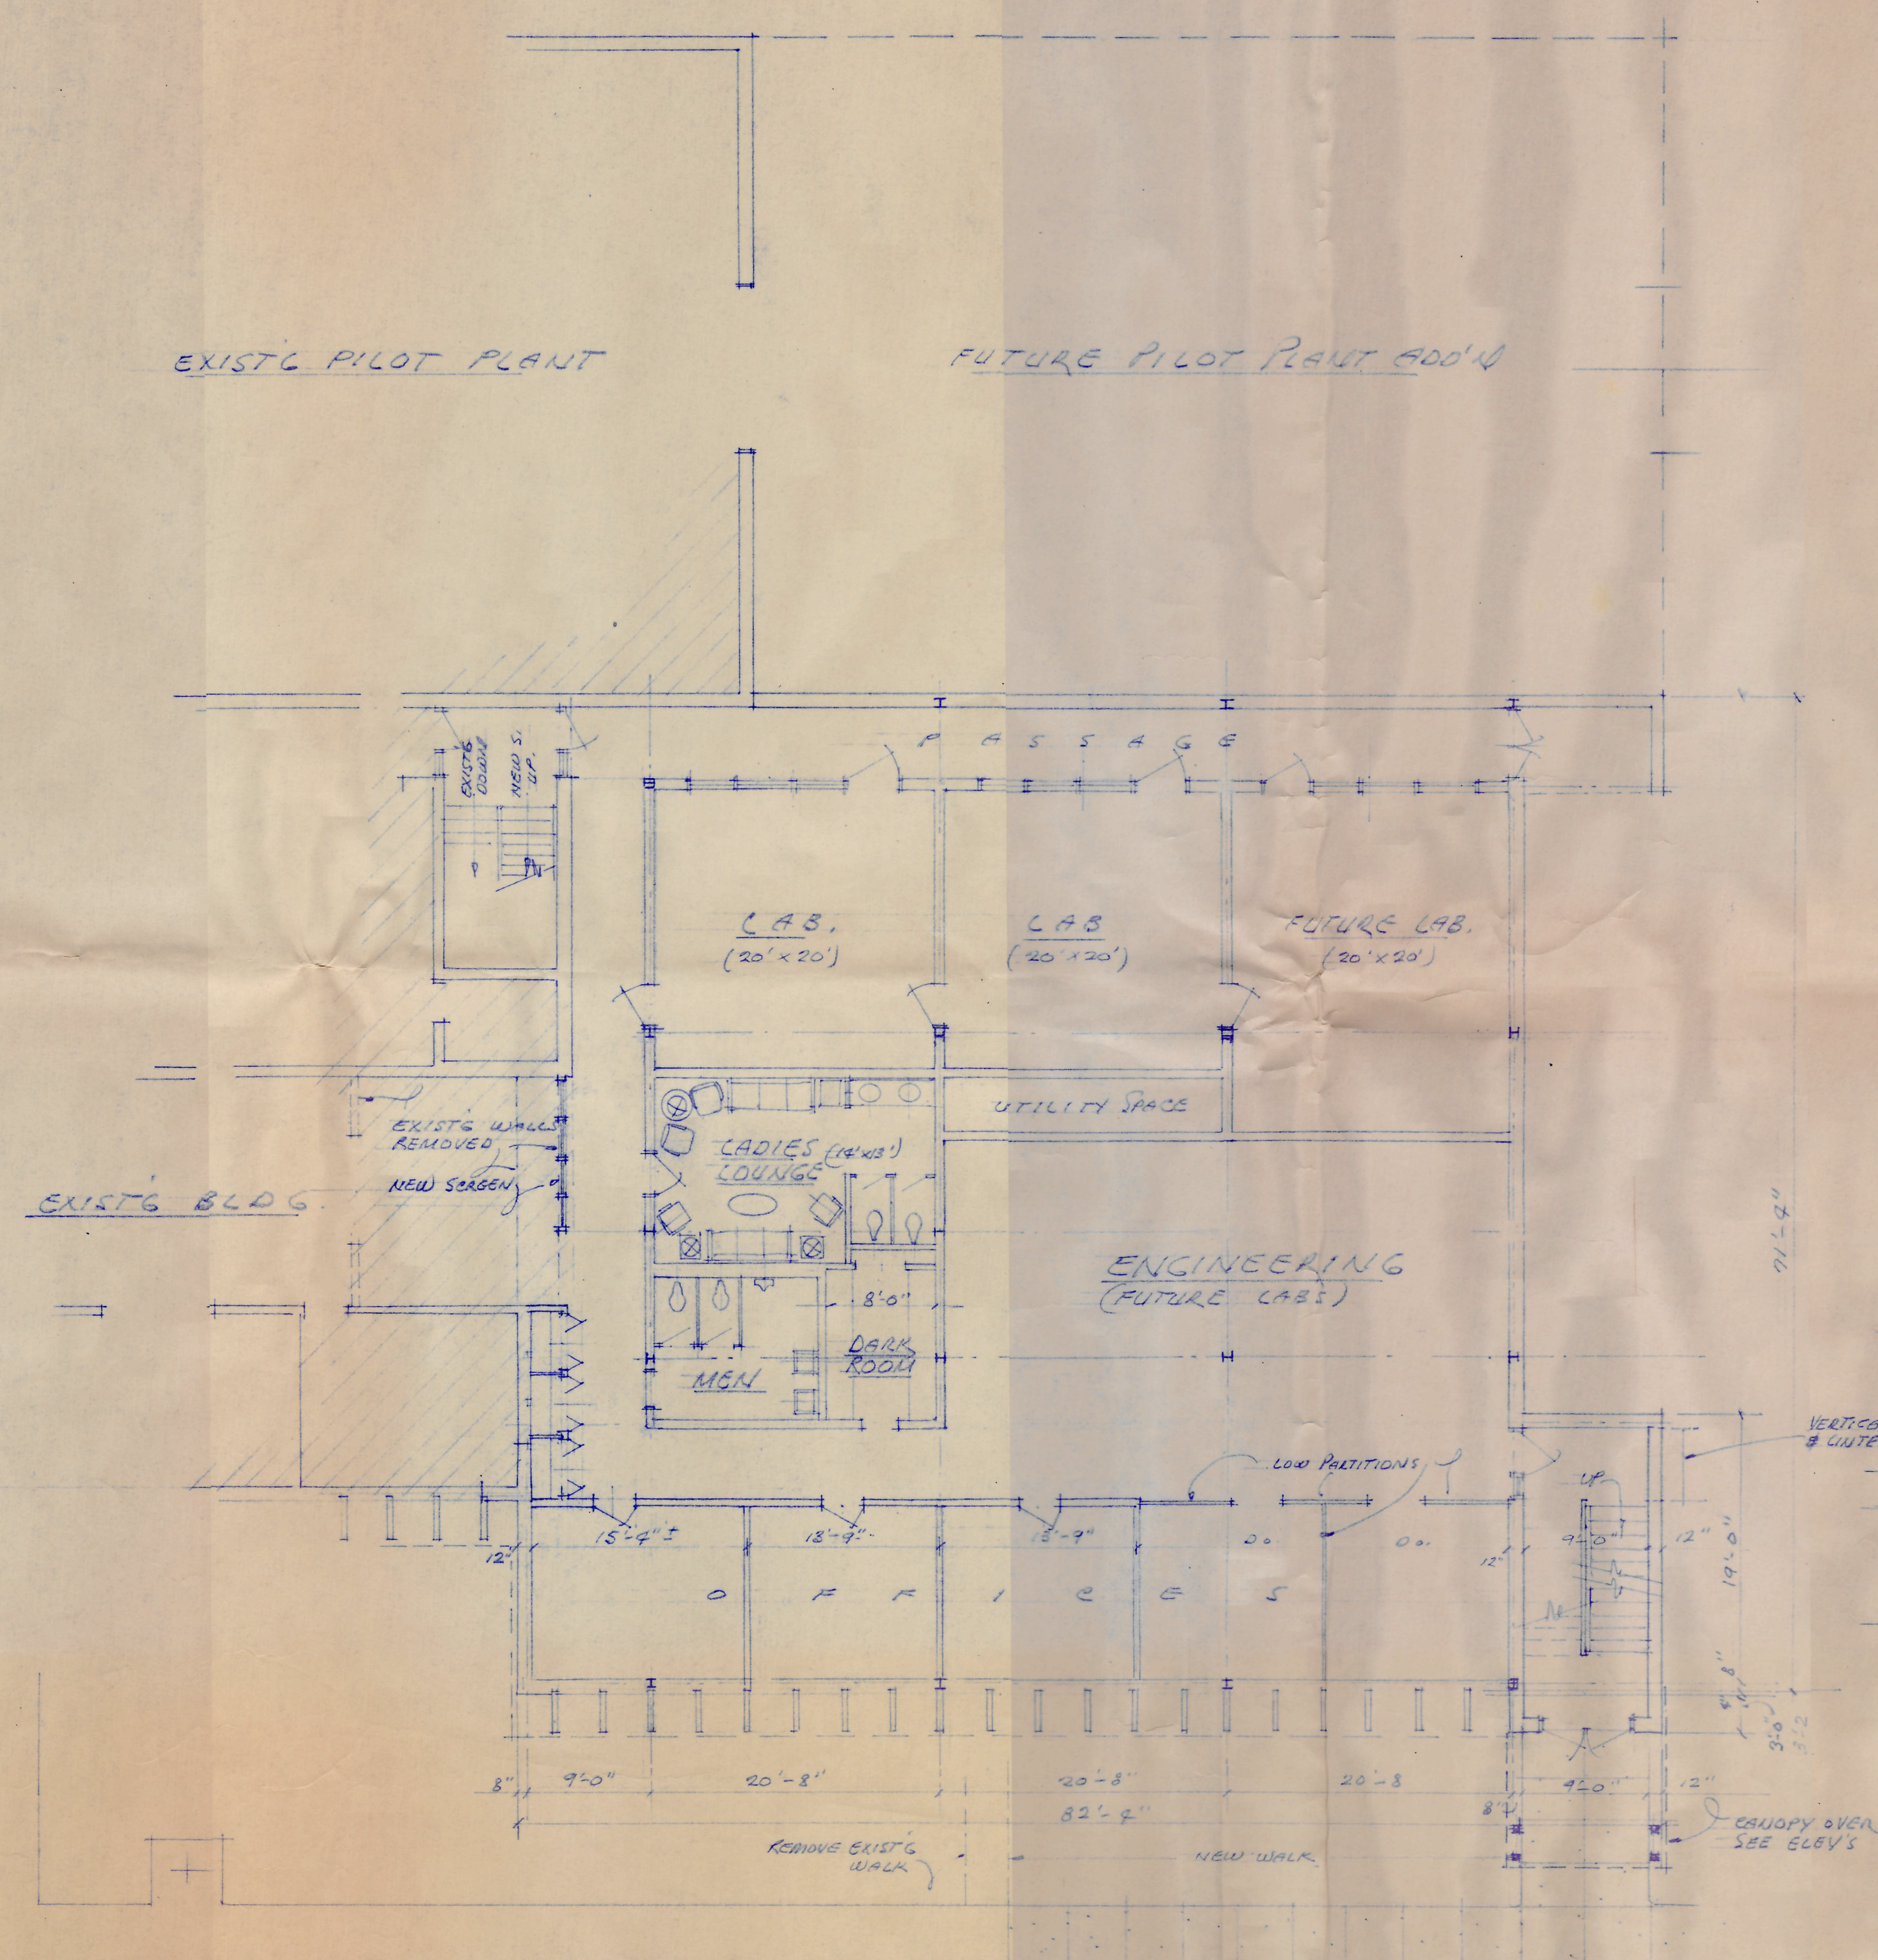

GROUND FLOOR PLAN
SCALE $\frac{3}{8}" = 1'-0"$
PROPOSED
FARMACED RESEARCH ADDITION

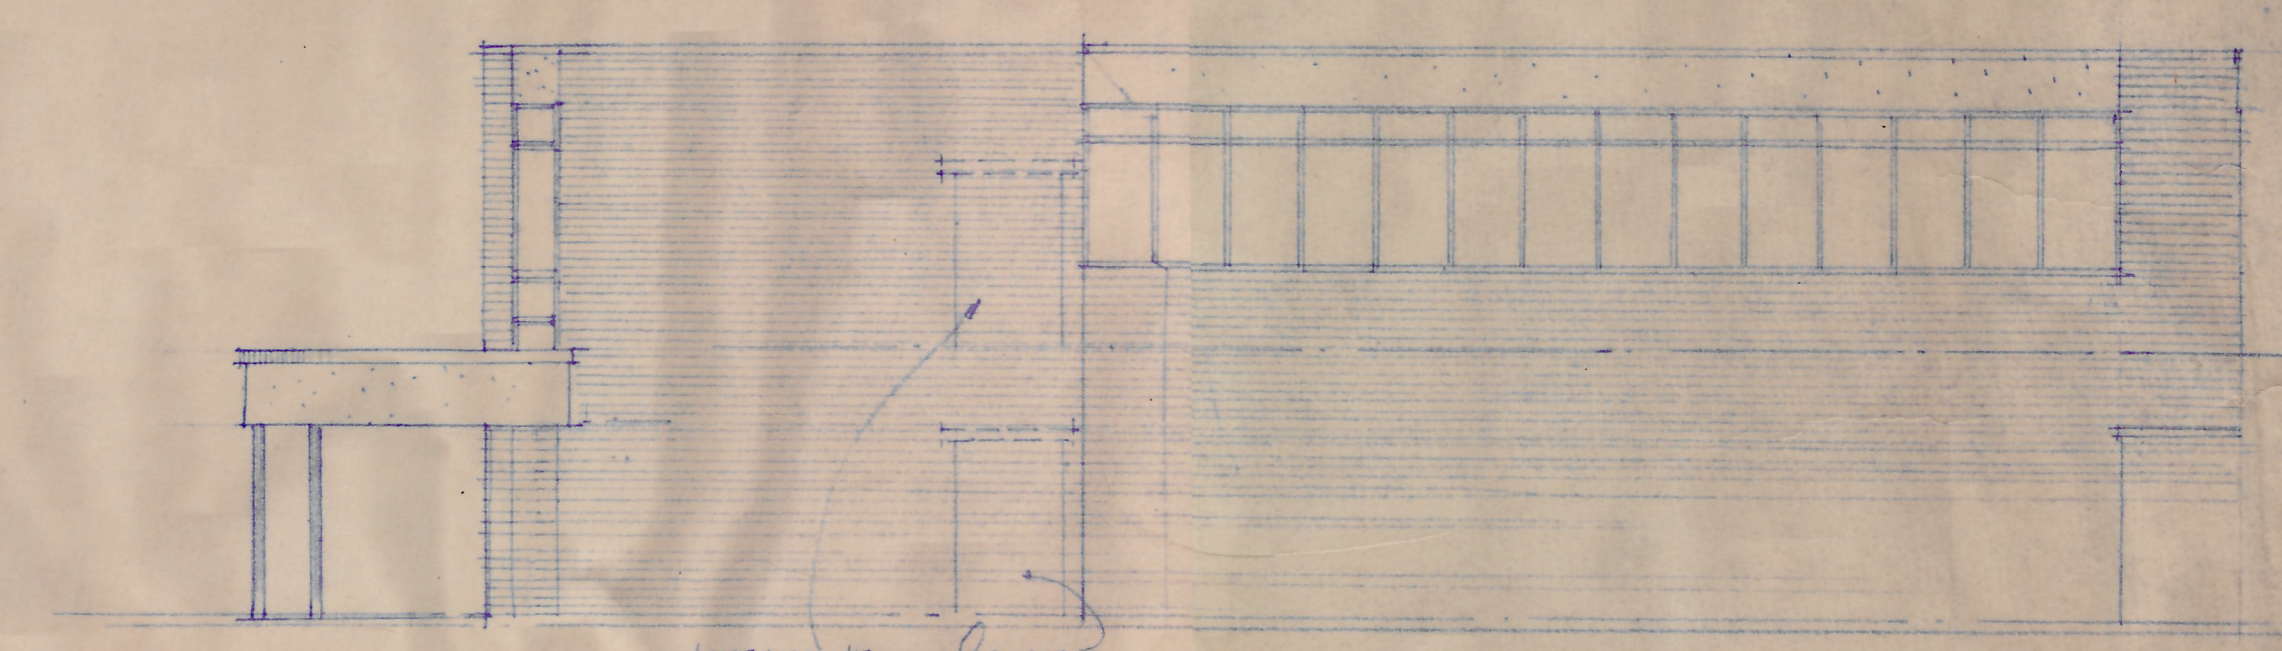


EAST ELEVATION
SCALE $\frac{3}{8}" = 1'-0"$
VERTICAL JTS AND LINTELS FOR FUTURE OPENINGS 4'-0" X 7'-2"

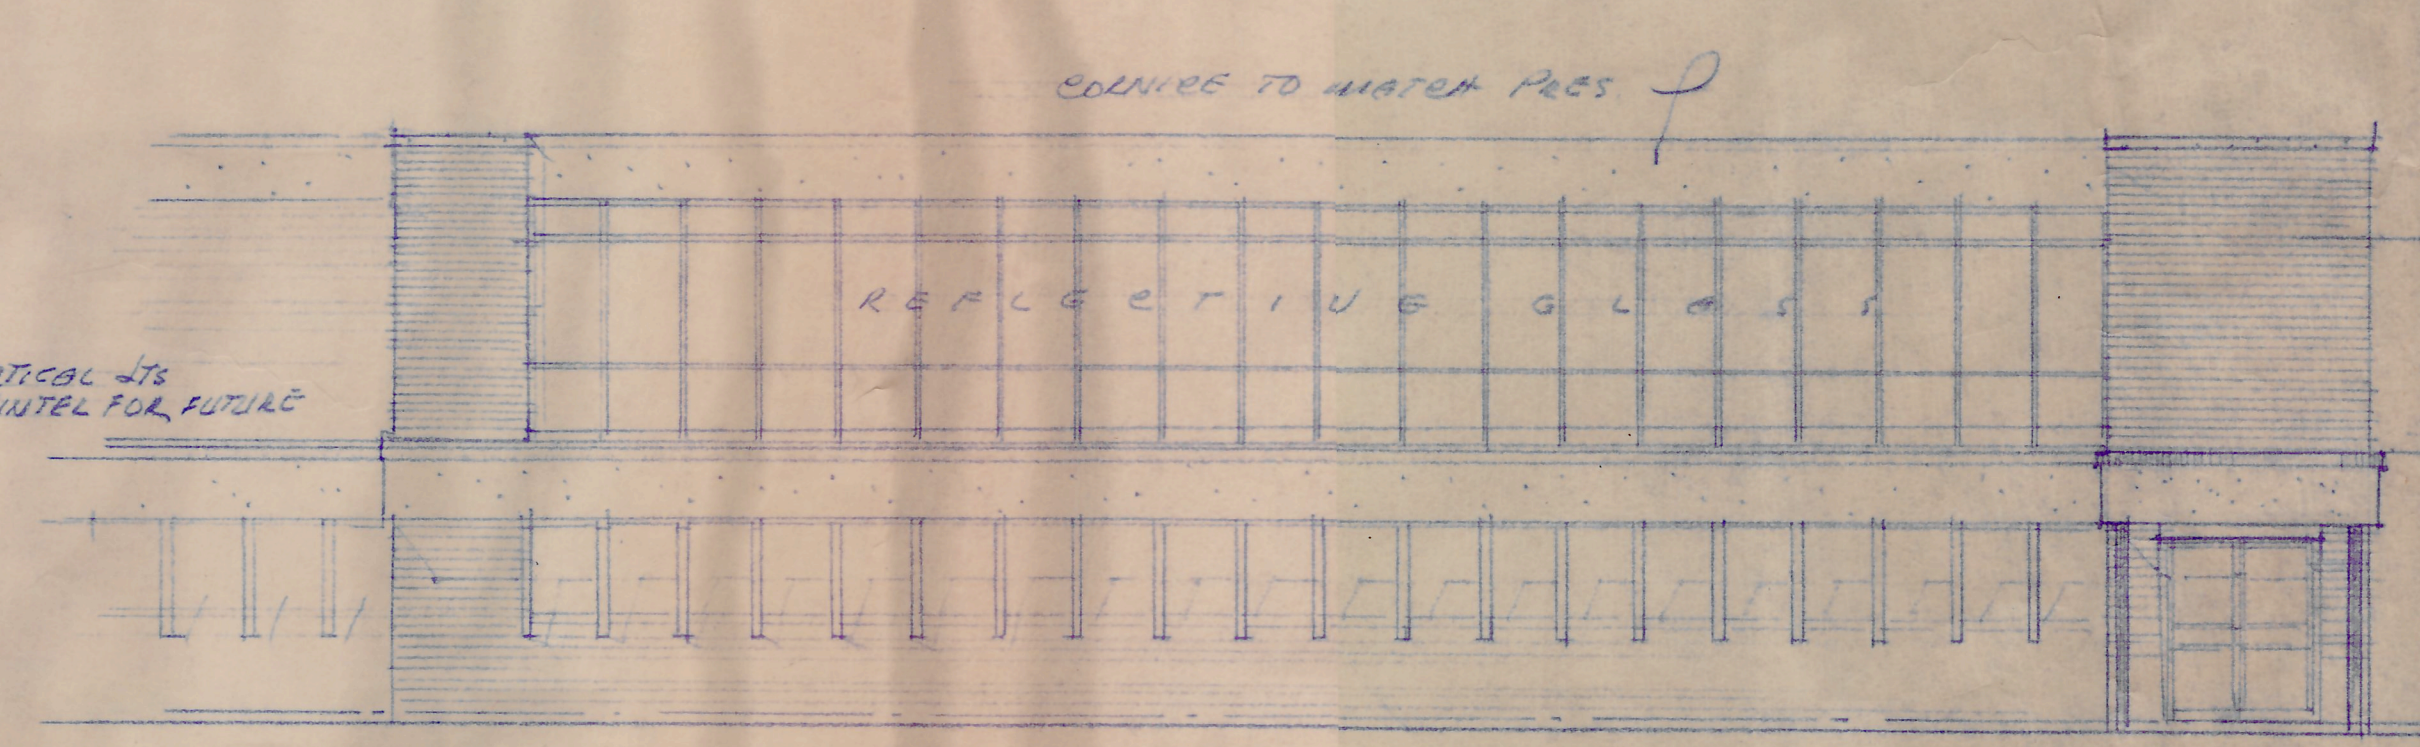

SOUTH ELEVATION
SCALE $\frac{3}{8}" = 1'-0"$
REFLECTIVE GLASS
CEILING 9'-0"
2ND FLR FIN. 11'-0"
1ST FLR FIN. 11'-0"

EXIST'G PILOT PLANT FUTURE ADD'N TO PILOT PLANT

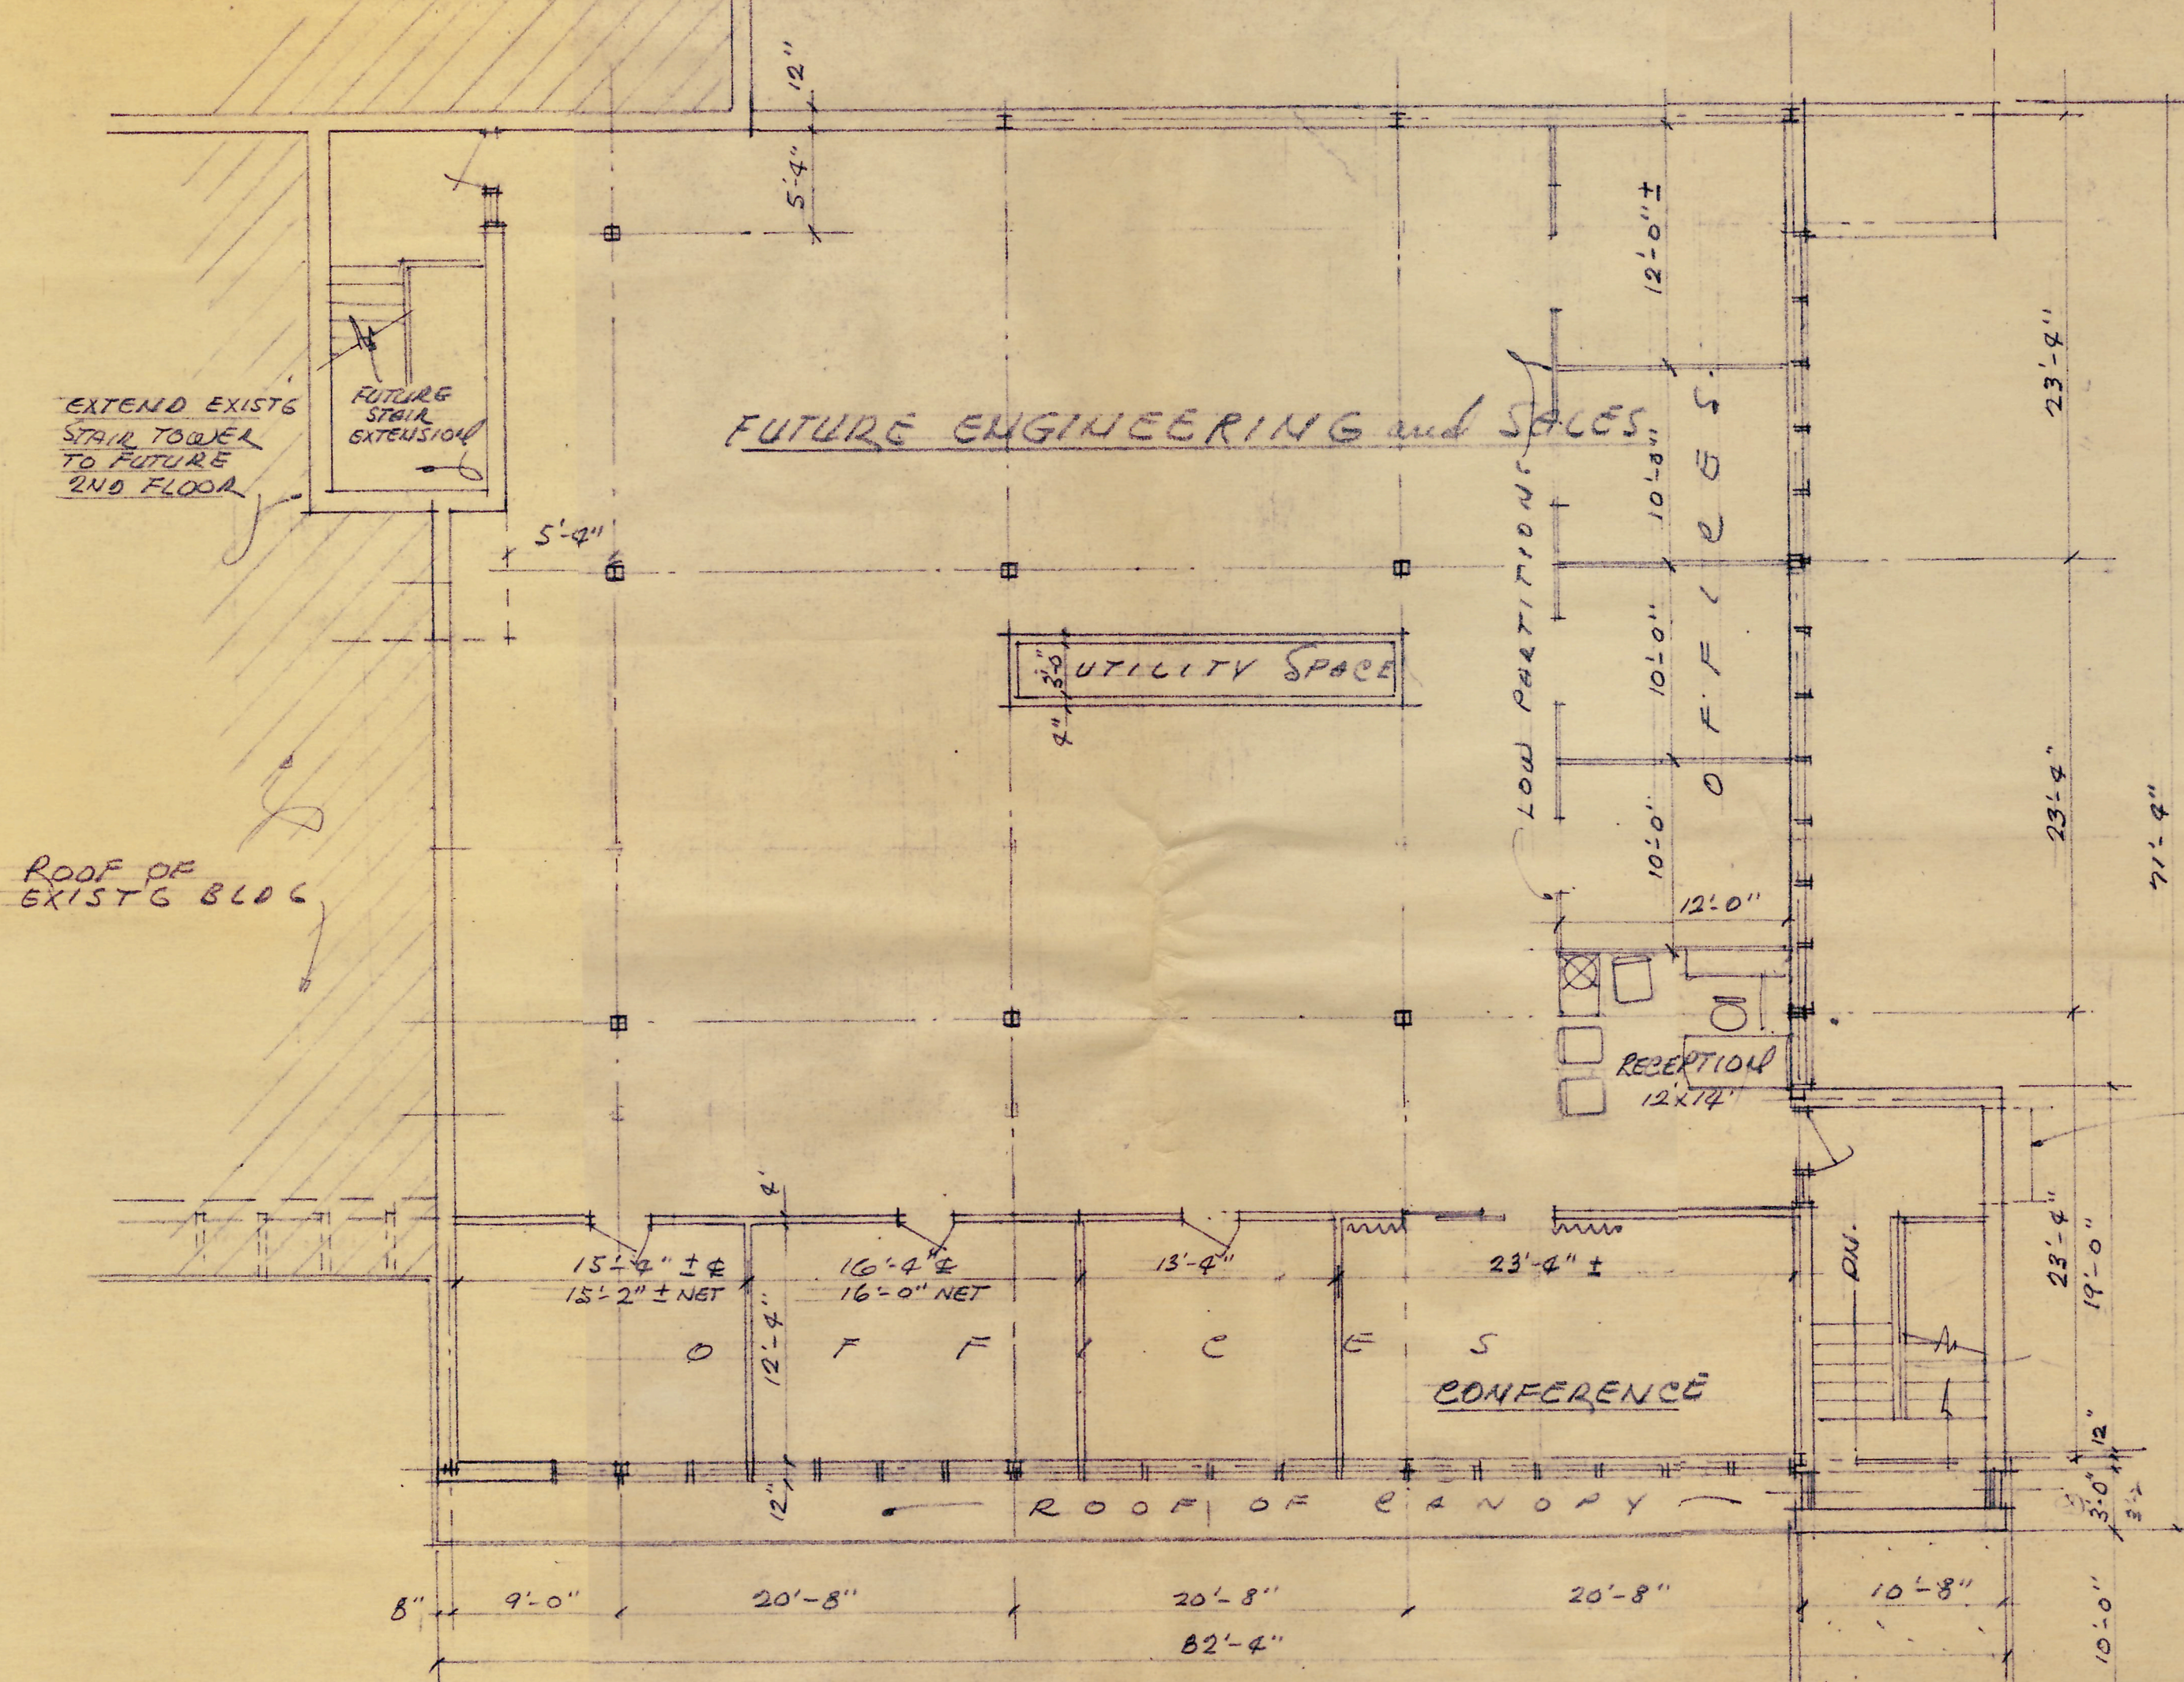

PLAN SHOWING
FUTURE SECOND FLOOR
SCALE $\frac{1}{8}'' = 1'-0''$

PROPOSED
FARMARCO RESEARCH ADDITION


1ST/2ND 11'-4" = 18R @ $7\frac{1}{2}''$
1ST/BSMT 11'-8" = 19R @ $7\frac{1}{2}''$

VERTICAL JTS and
LINTEL FOR FUTURE


SECTION THRU
NEW STAIR
SCALE $\frac{1}{8}'' = 1'-0''$

NOTE: PROVIDE KNOCK-OUT PANELS
FOR FUTURE DOORS IN STAIR
TOWER

14jun 2-13-73

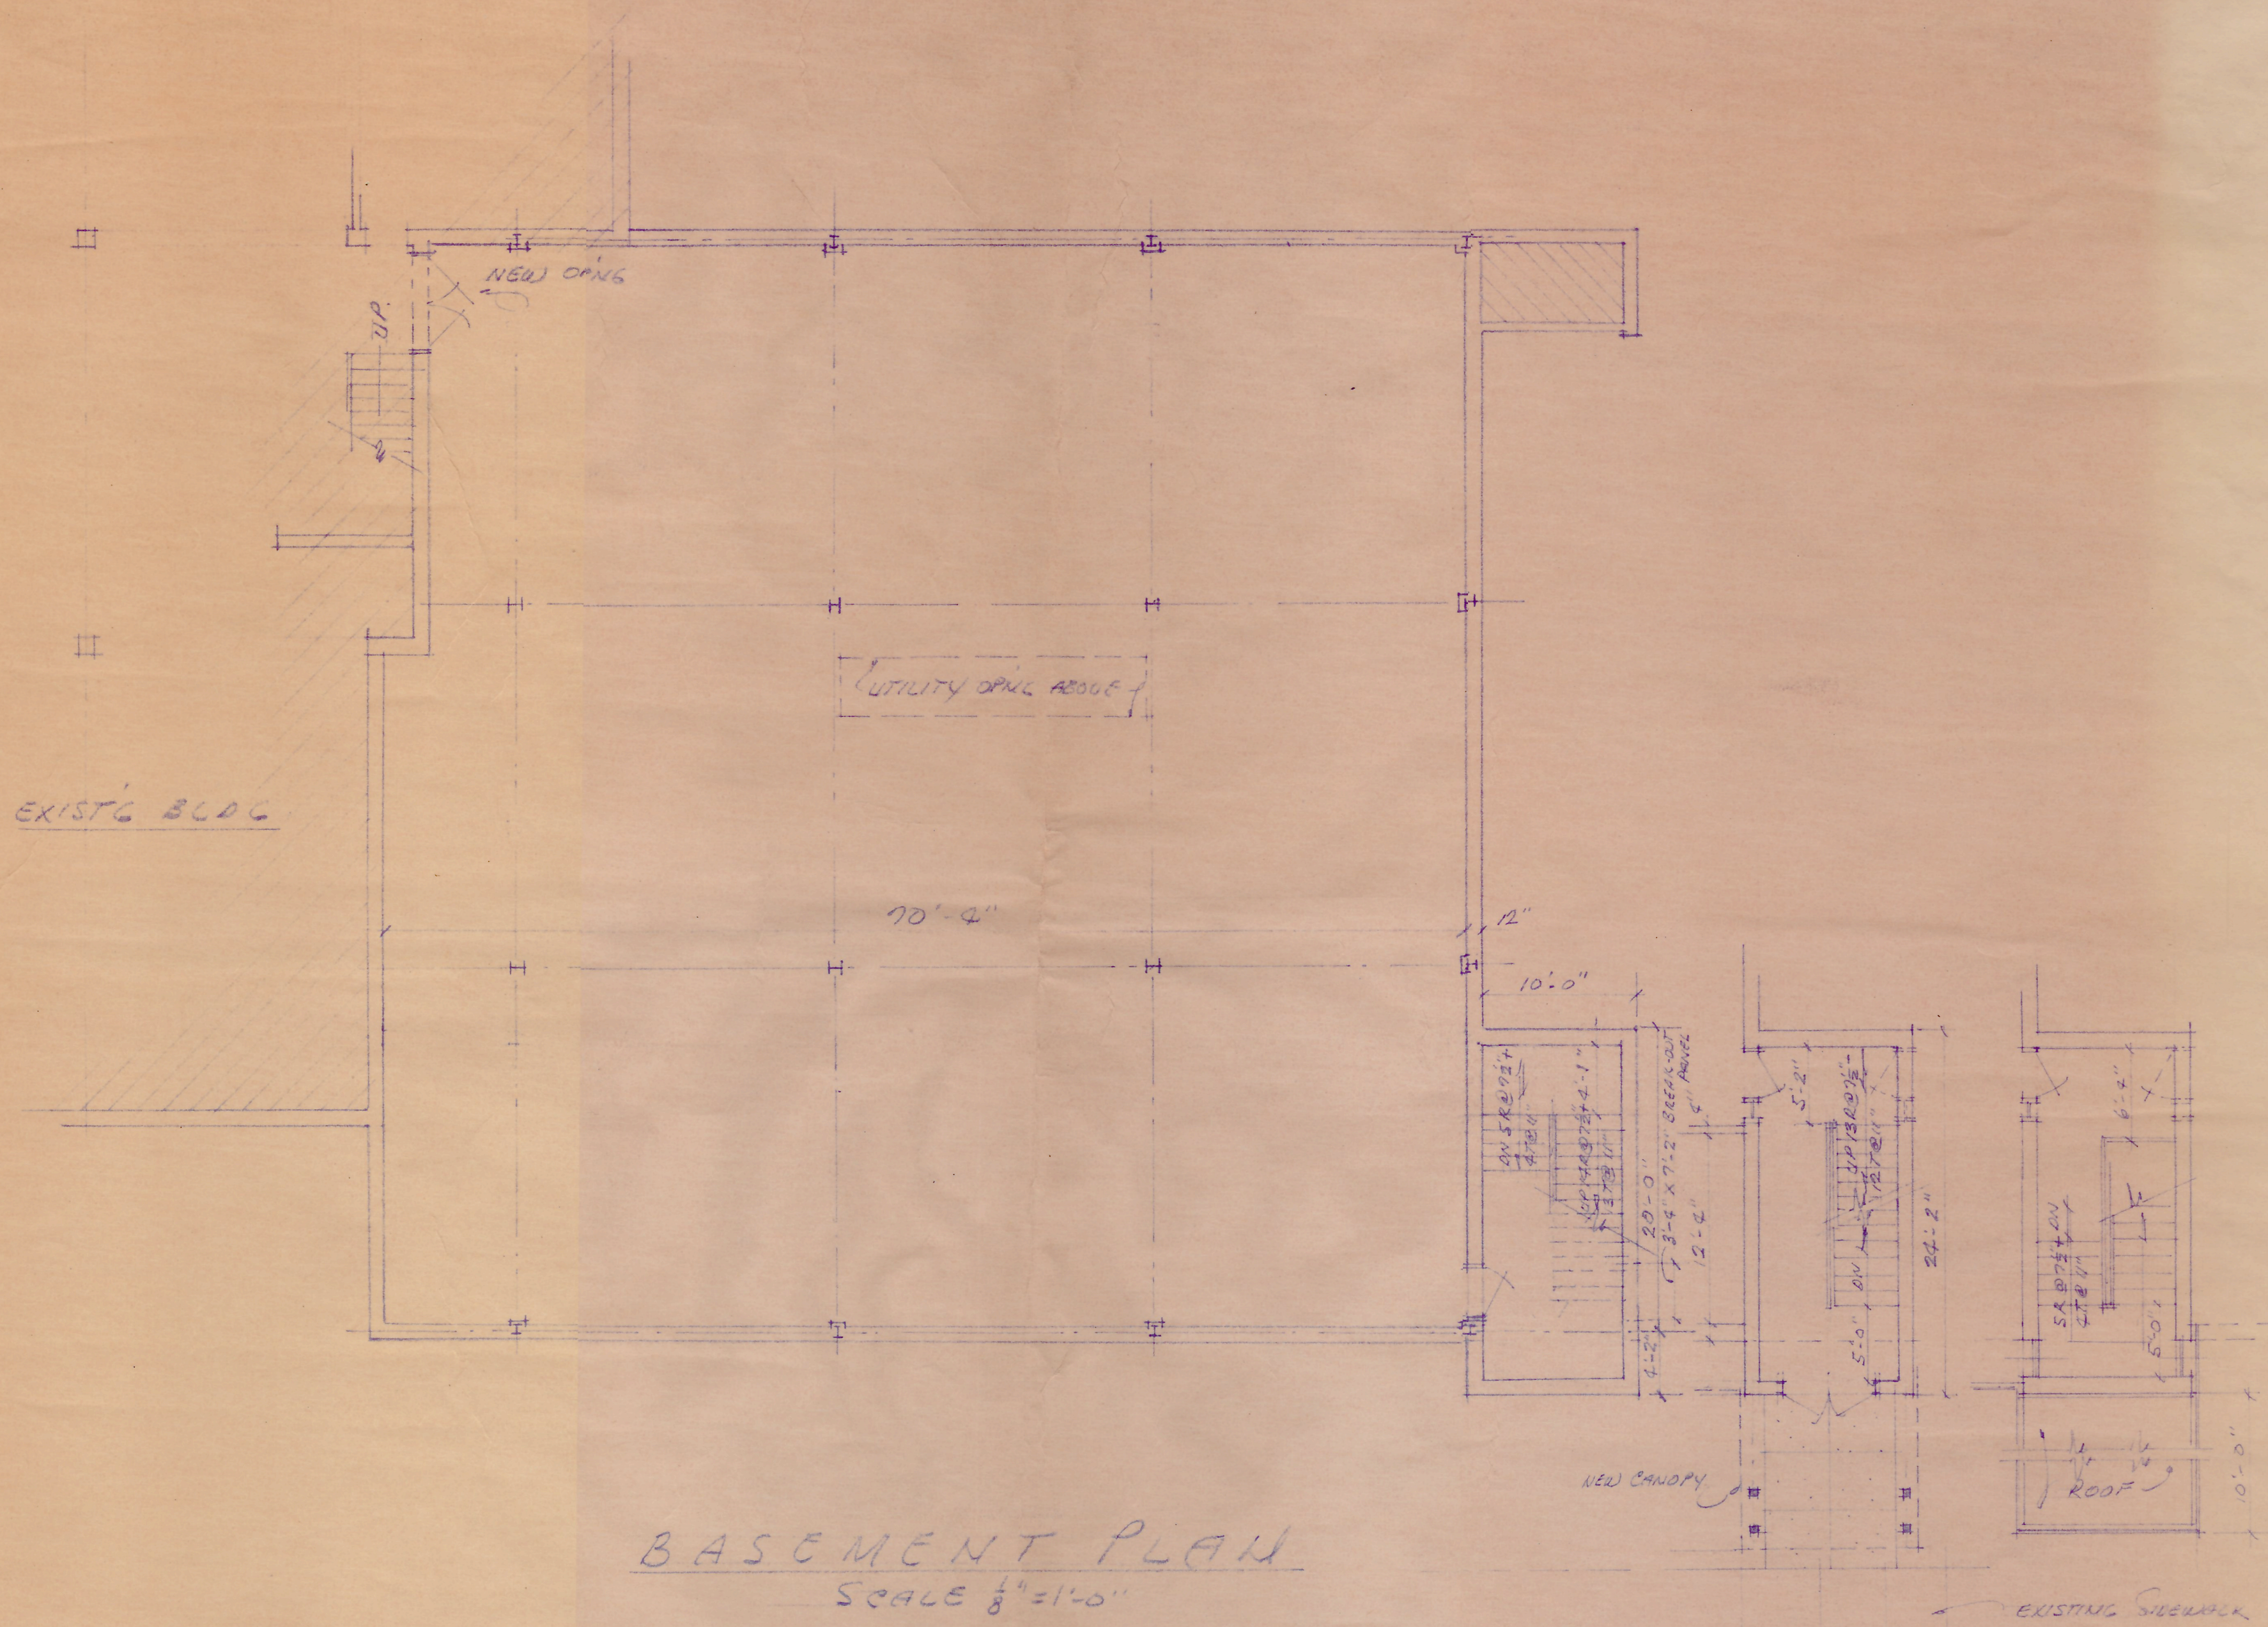

MILLER • HIETT • DRONBERGER • ARBUCKLE and WALKER
architects and engineers HUTCHINSON, KORNBLAU

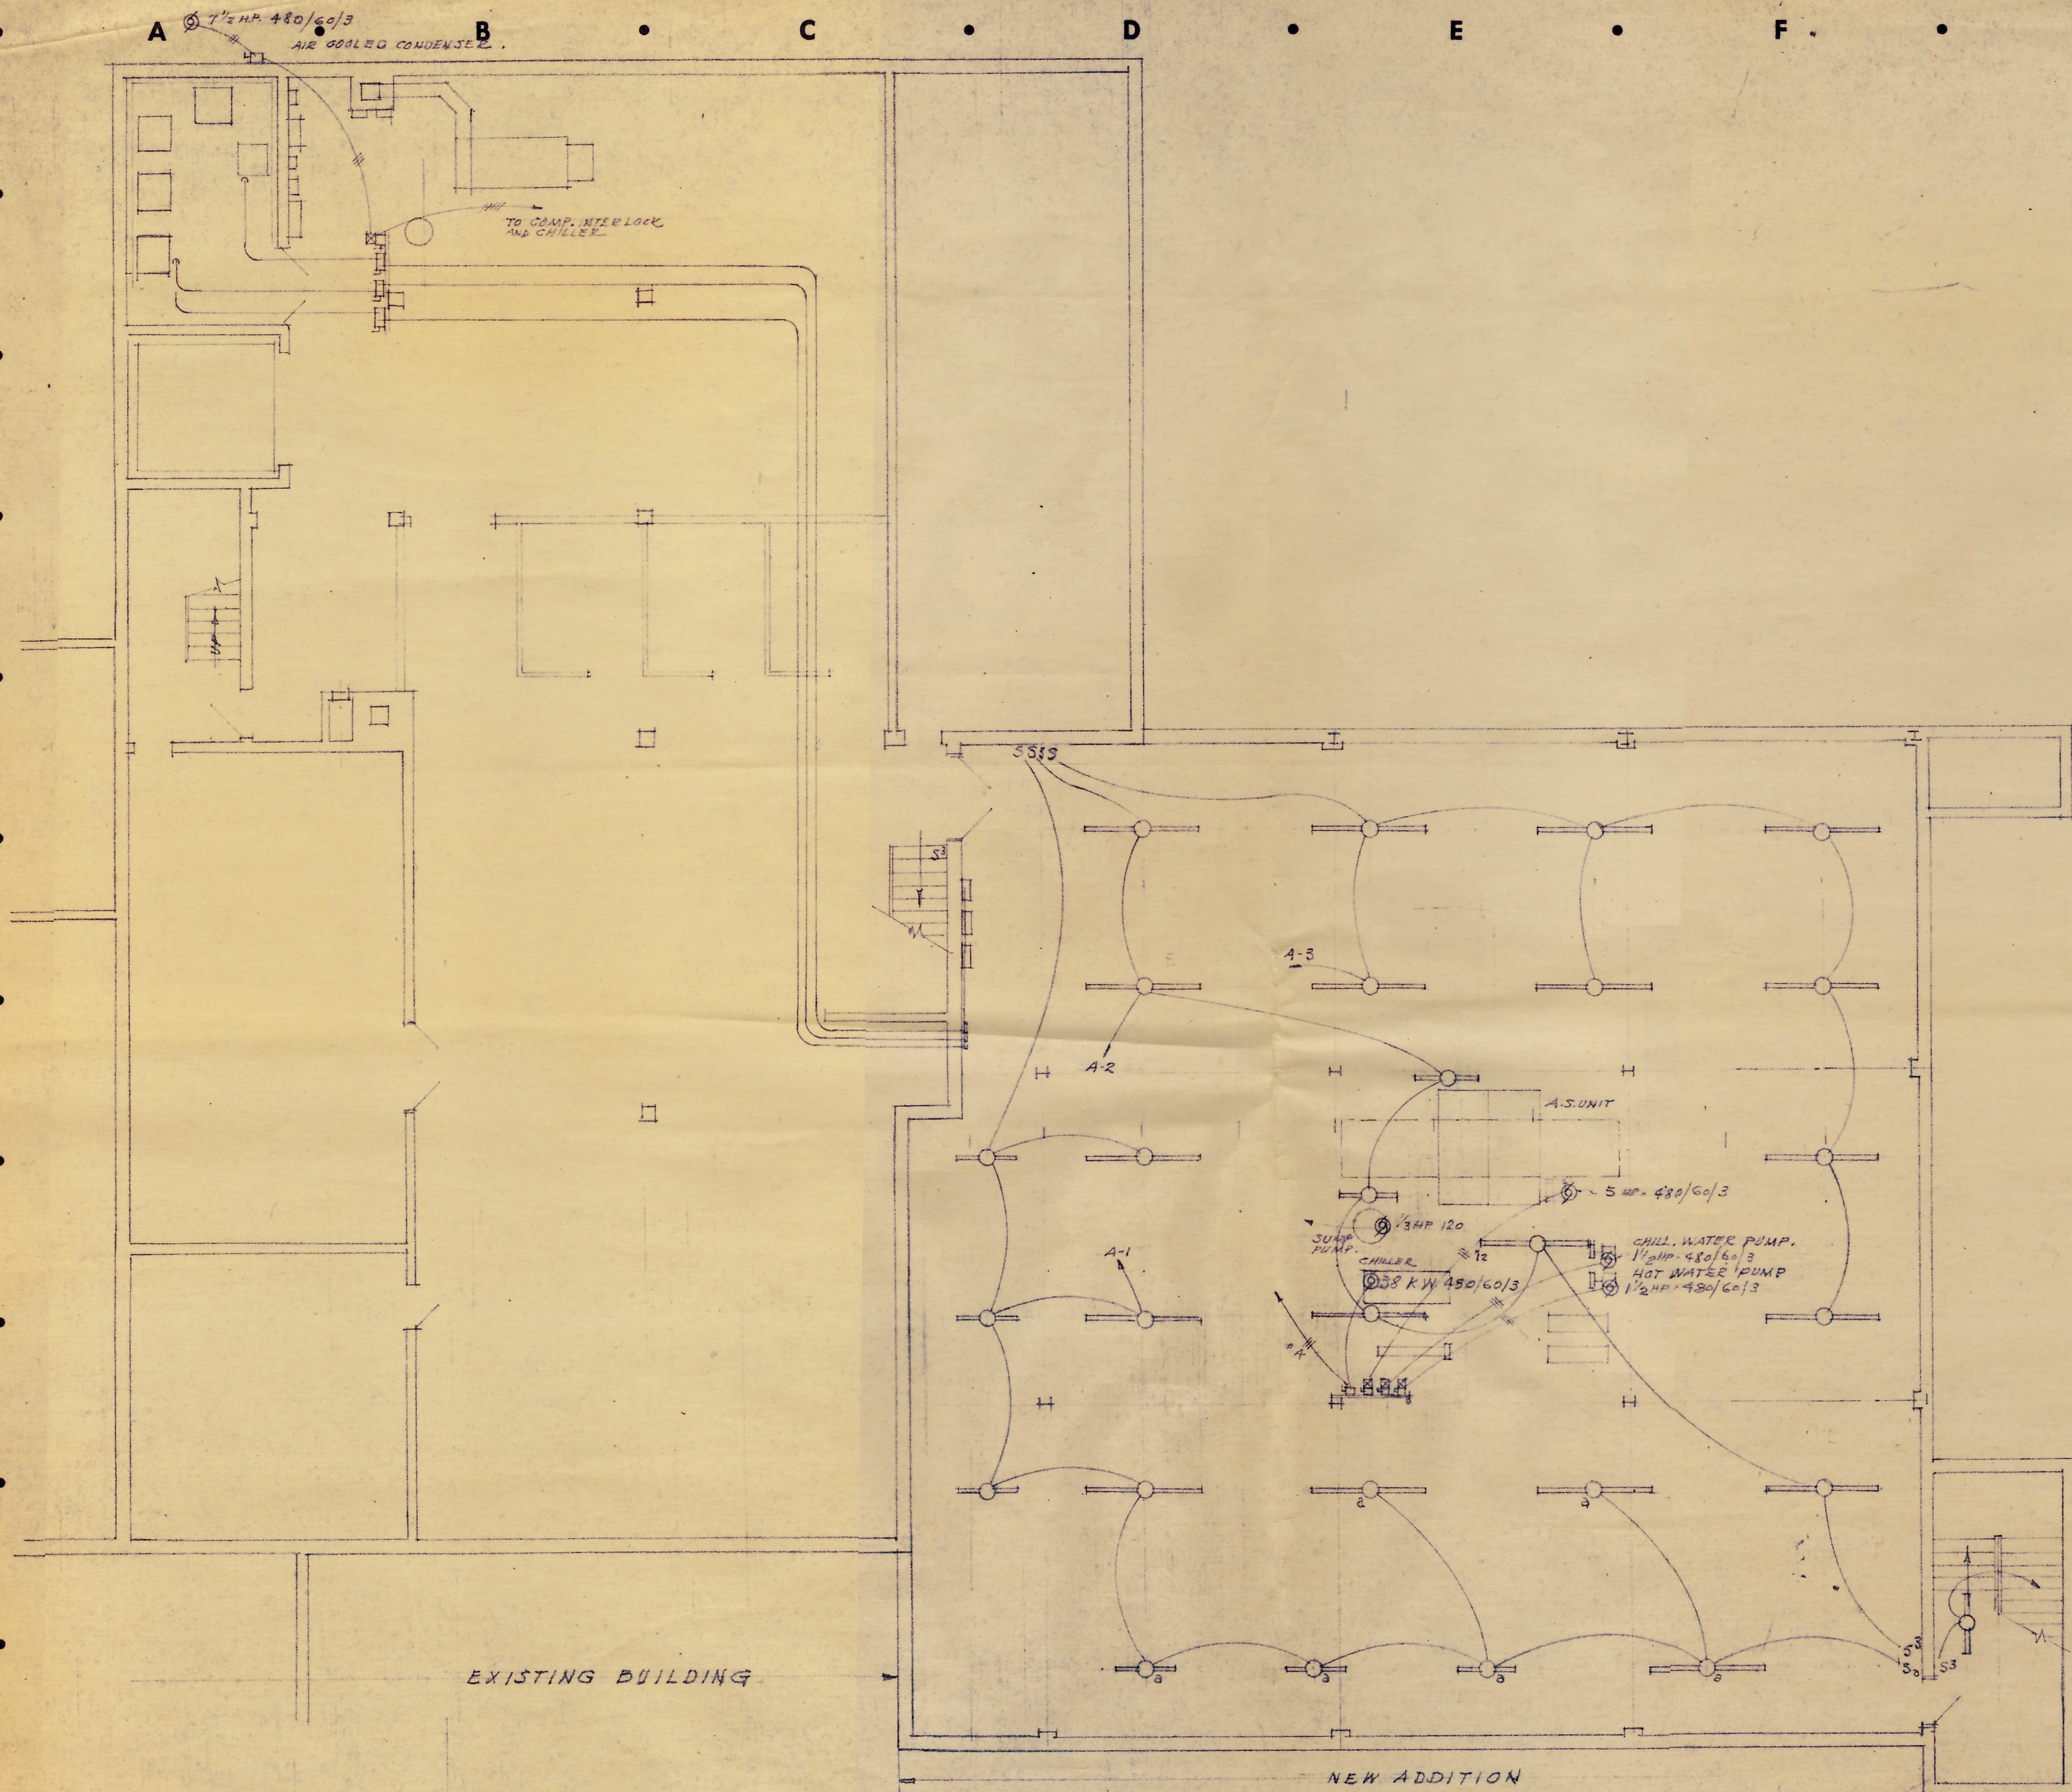

BASEMENT ELECTRICAL PLAN
 SCALE 1/8" = 1'-0"

MILLER • HIETT • DRONBERGER • ARBUCKLE and WALKER
 architects and engineers
 hutchinson, kansas

A

B


C

D


E

F

H

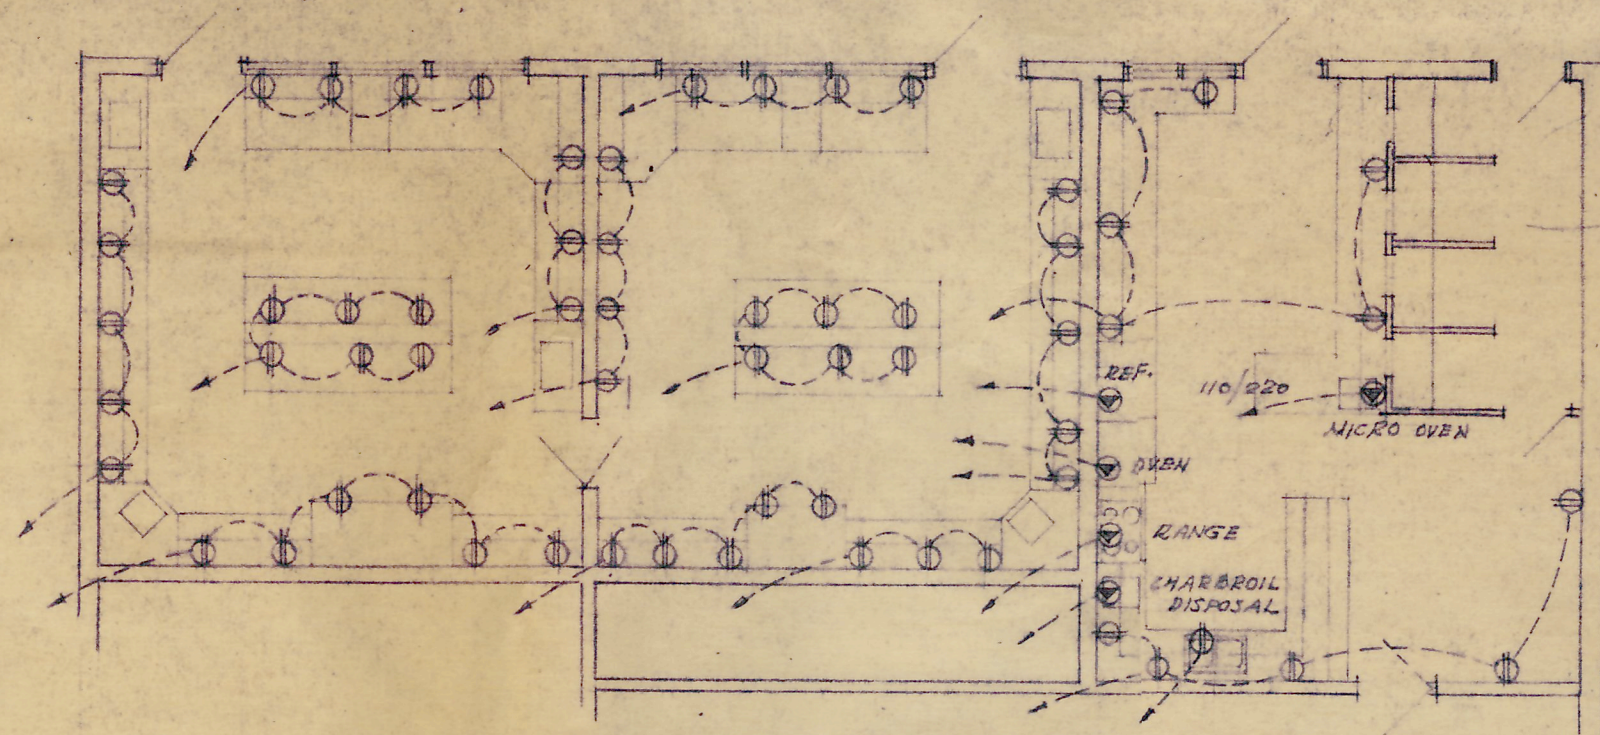



LABRATORIES ELECTRICAL OUTLET PLAN
SCALE 1/8" = 1'-0"

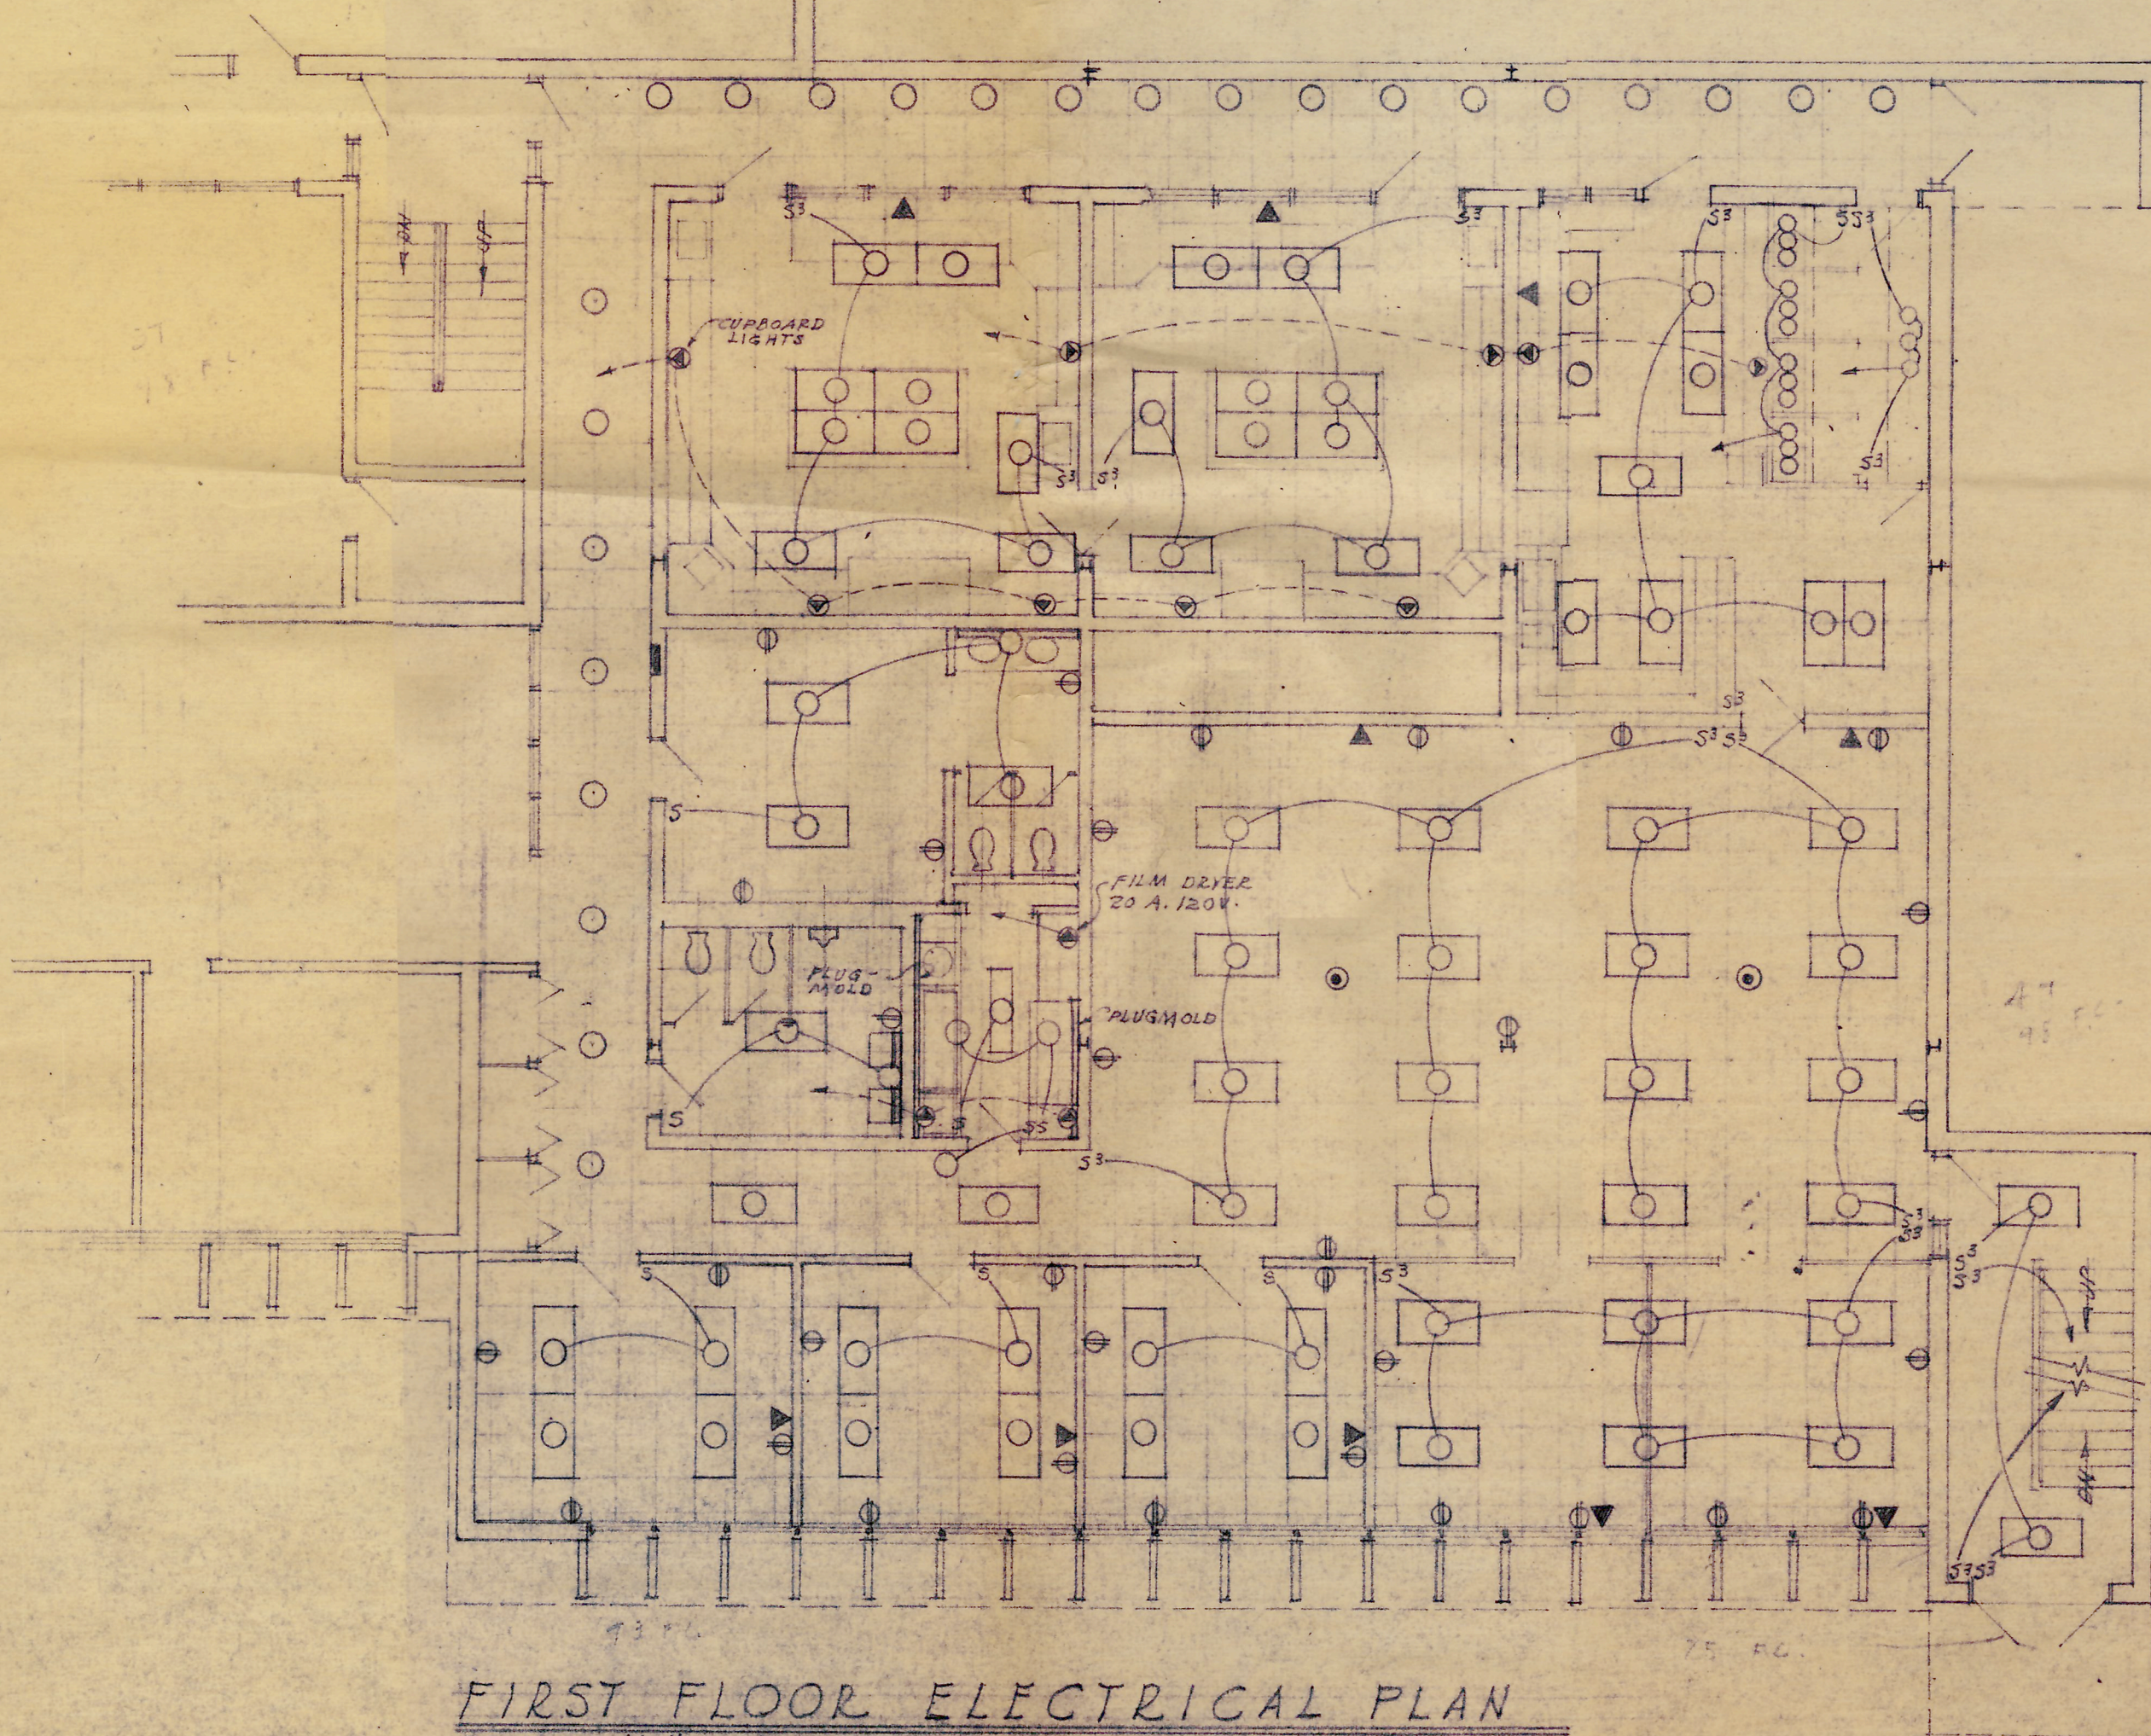

FIRST FLOOR ELECTRICAL PLAN
SCALE 1/8" = 1'-0"

MILLER • HIETT • DRONBERGER • ARBUCKLE and WALKER
architects and engineers, hutchinson, kennedy

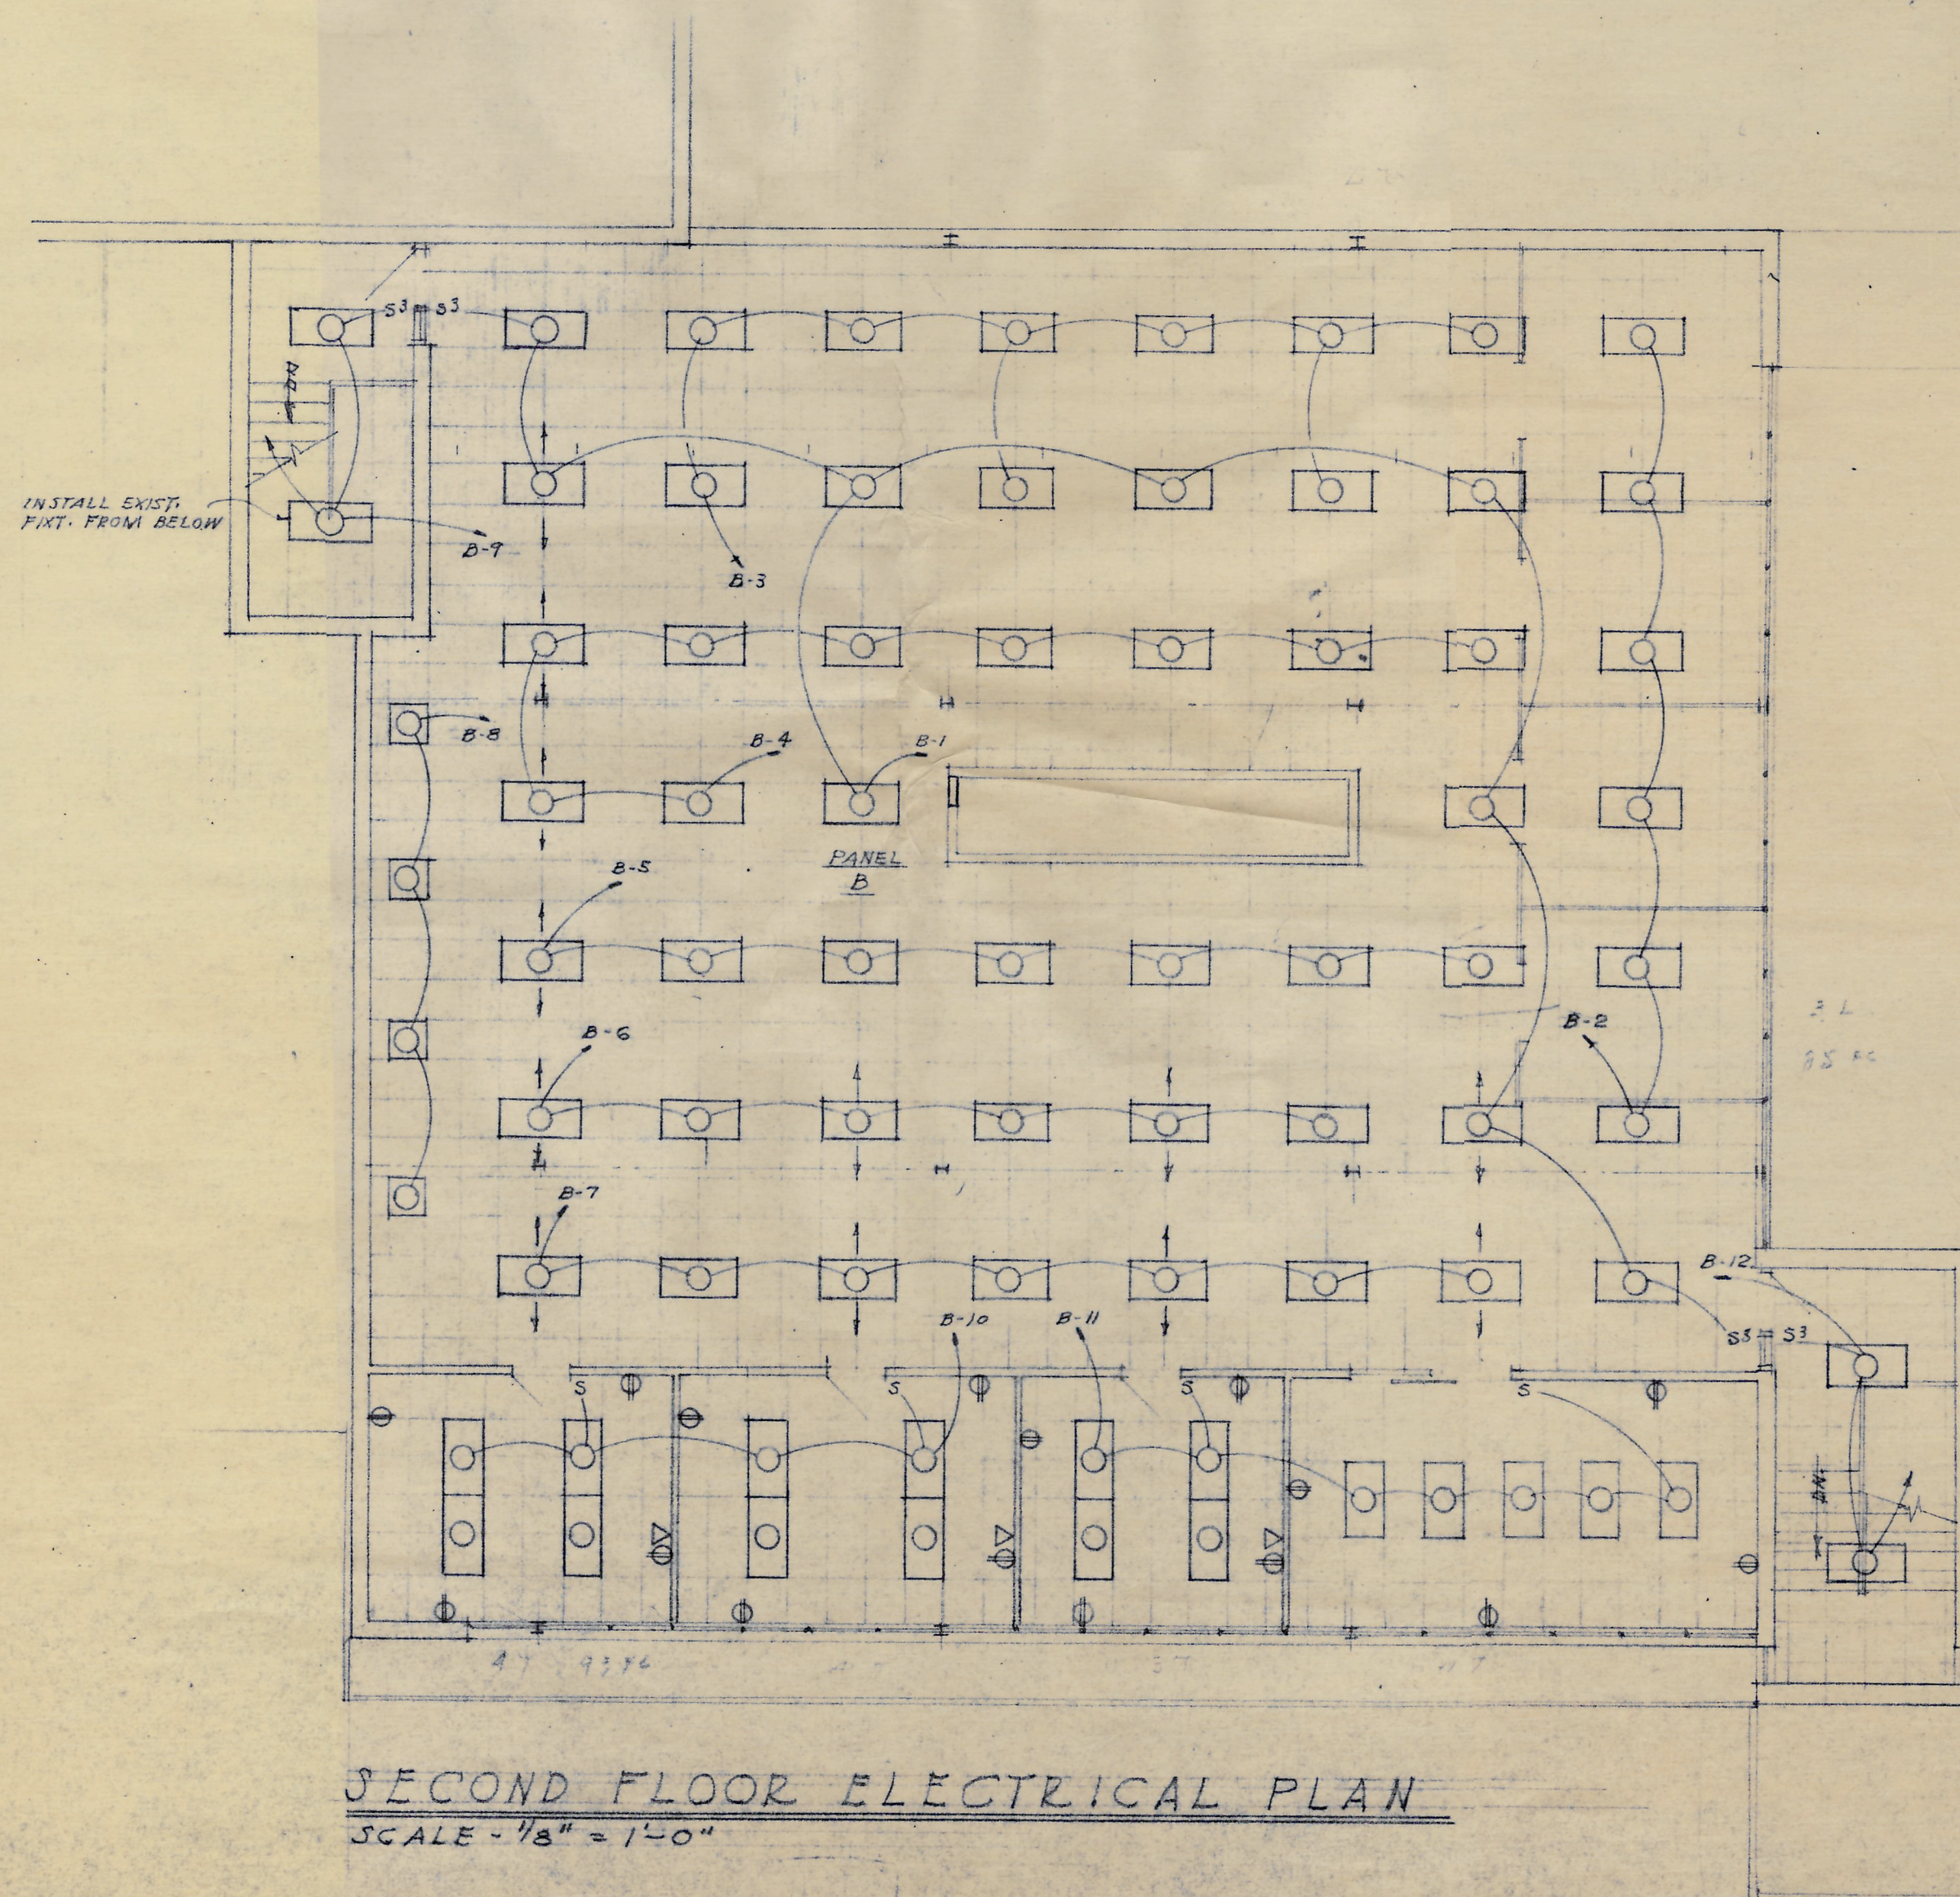

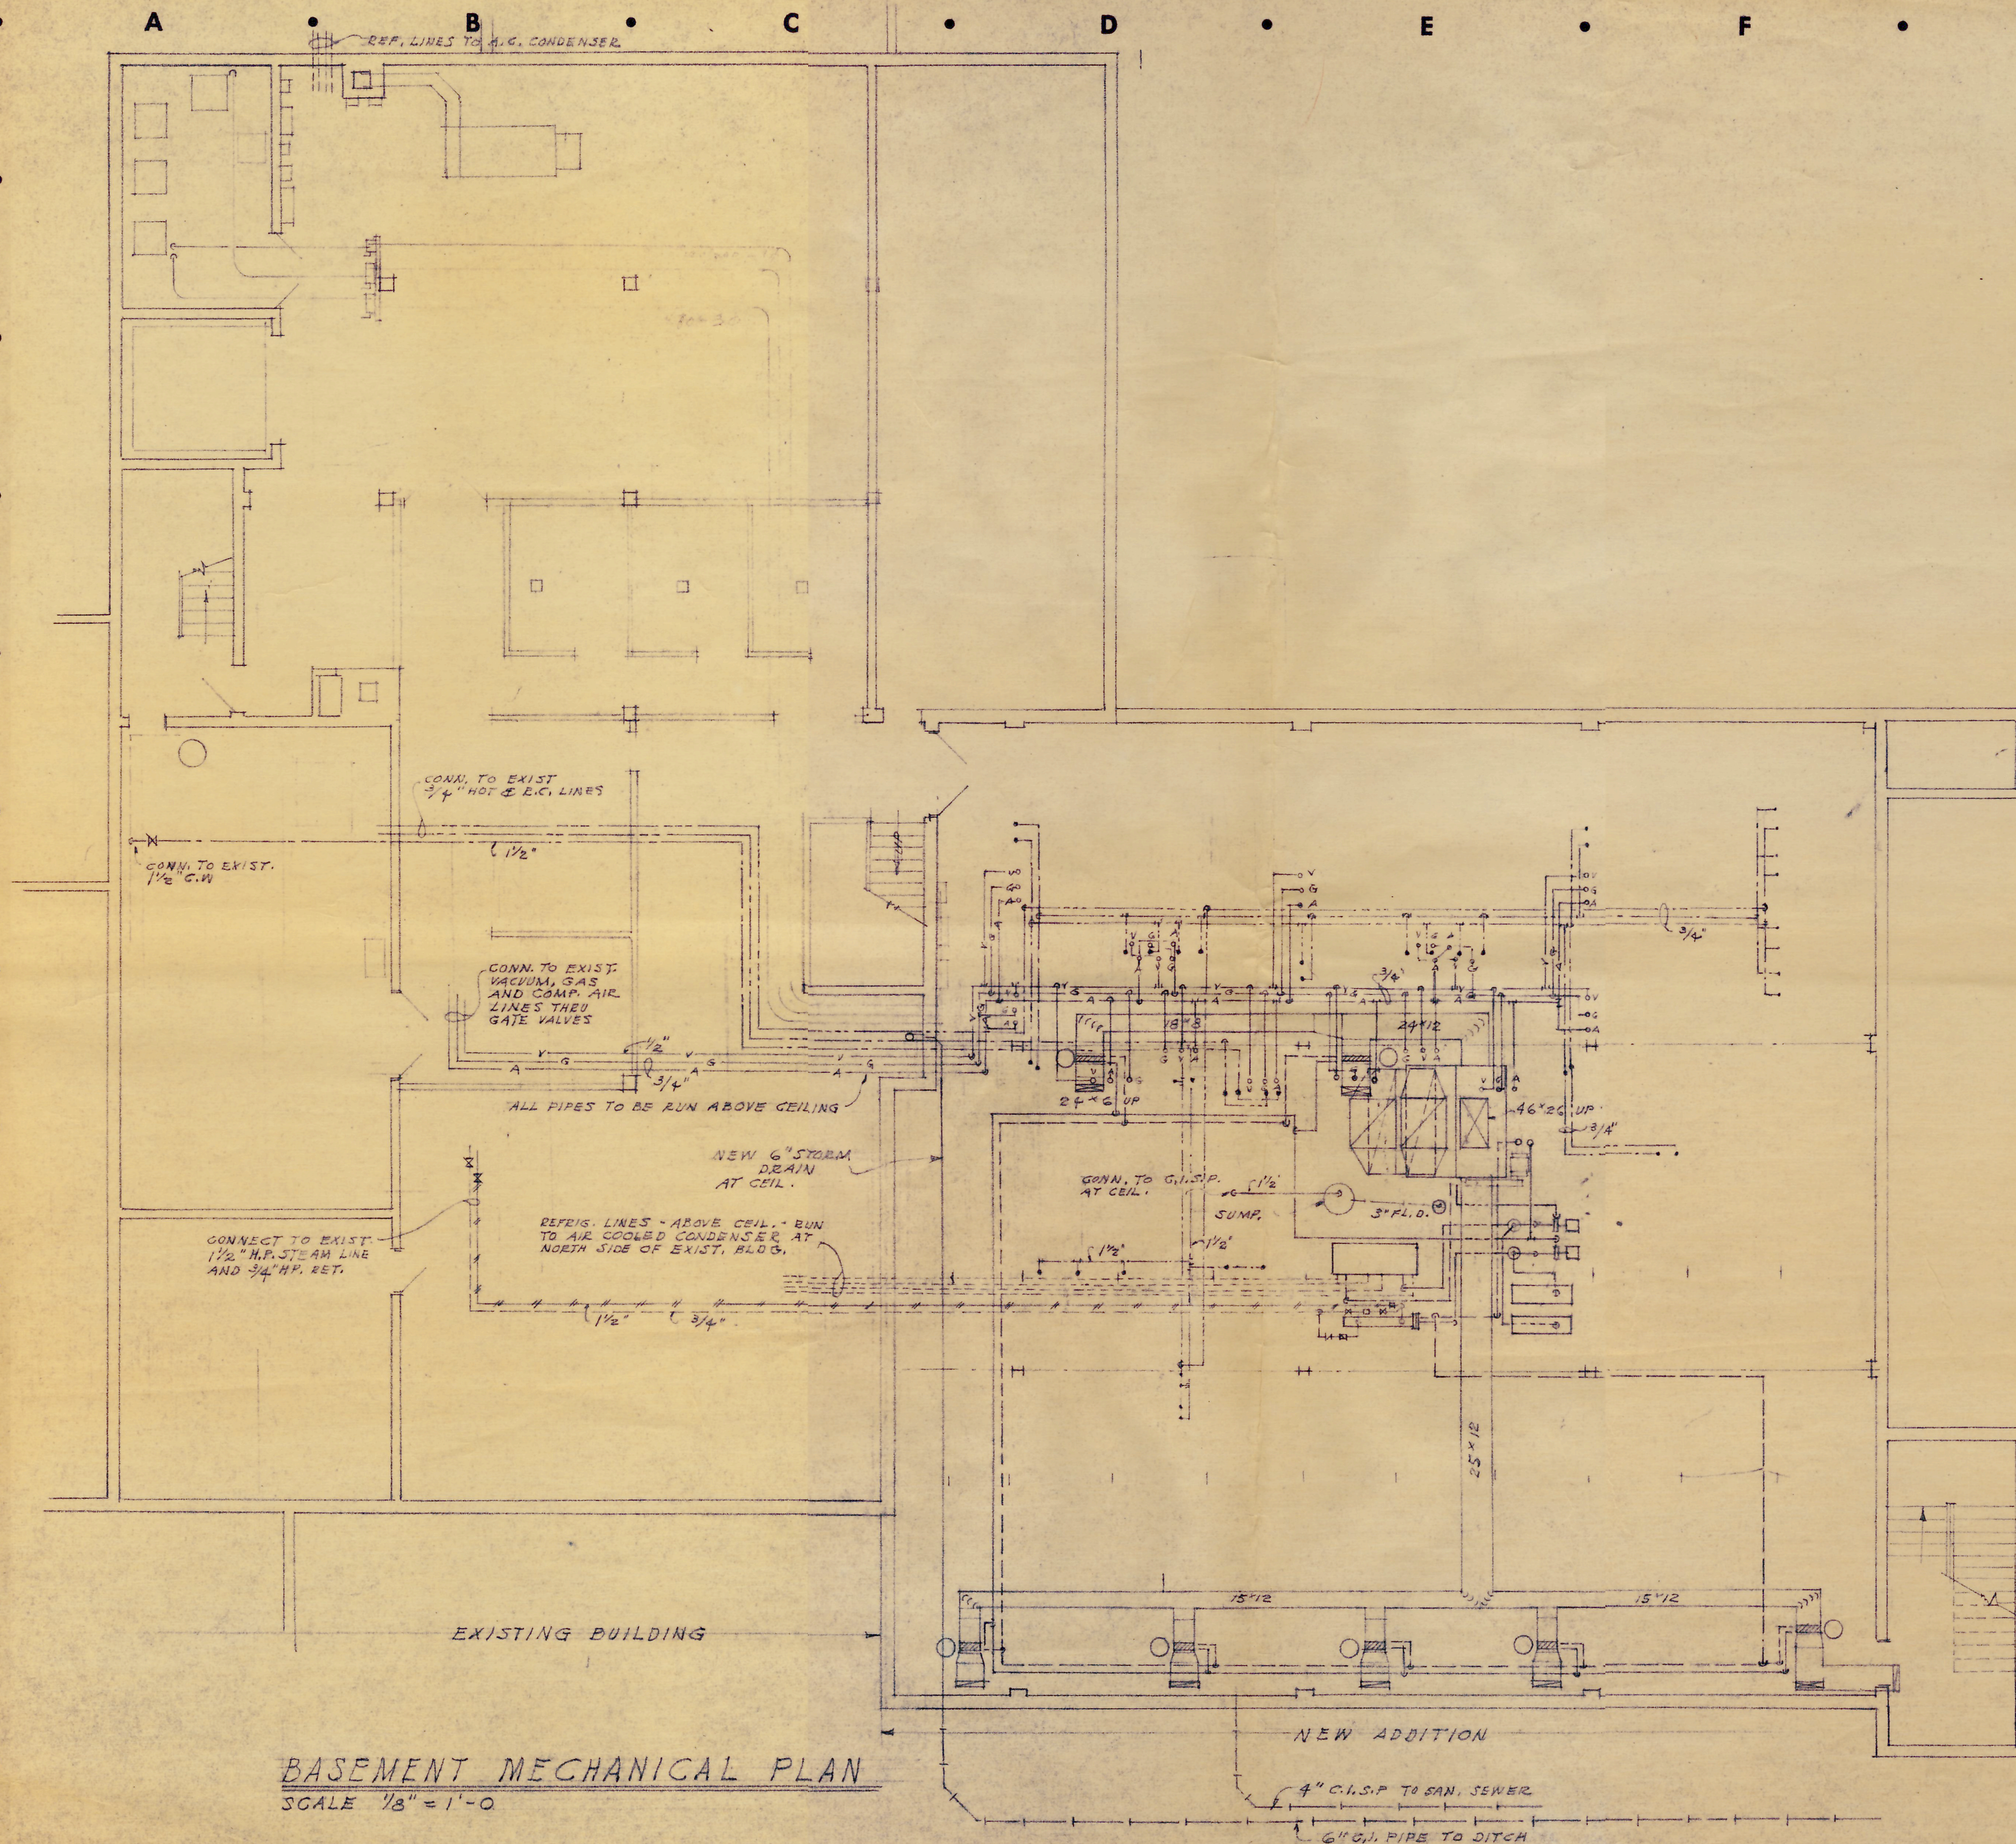

MILLER • HIETT • DRONBERGER • ARBUCKLE and WALKER
 ENGINEERS

A

B

C


D

E

F

G

H

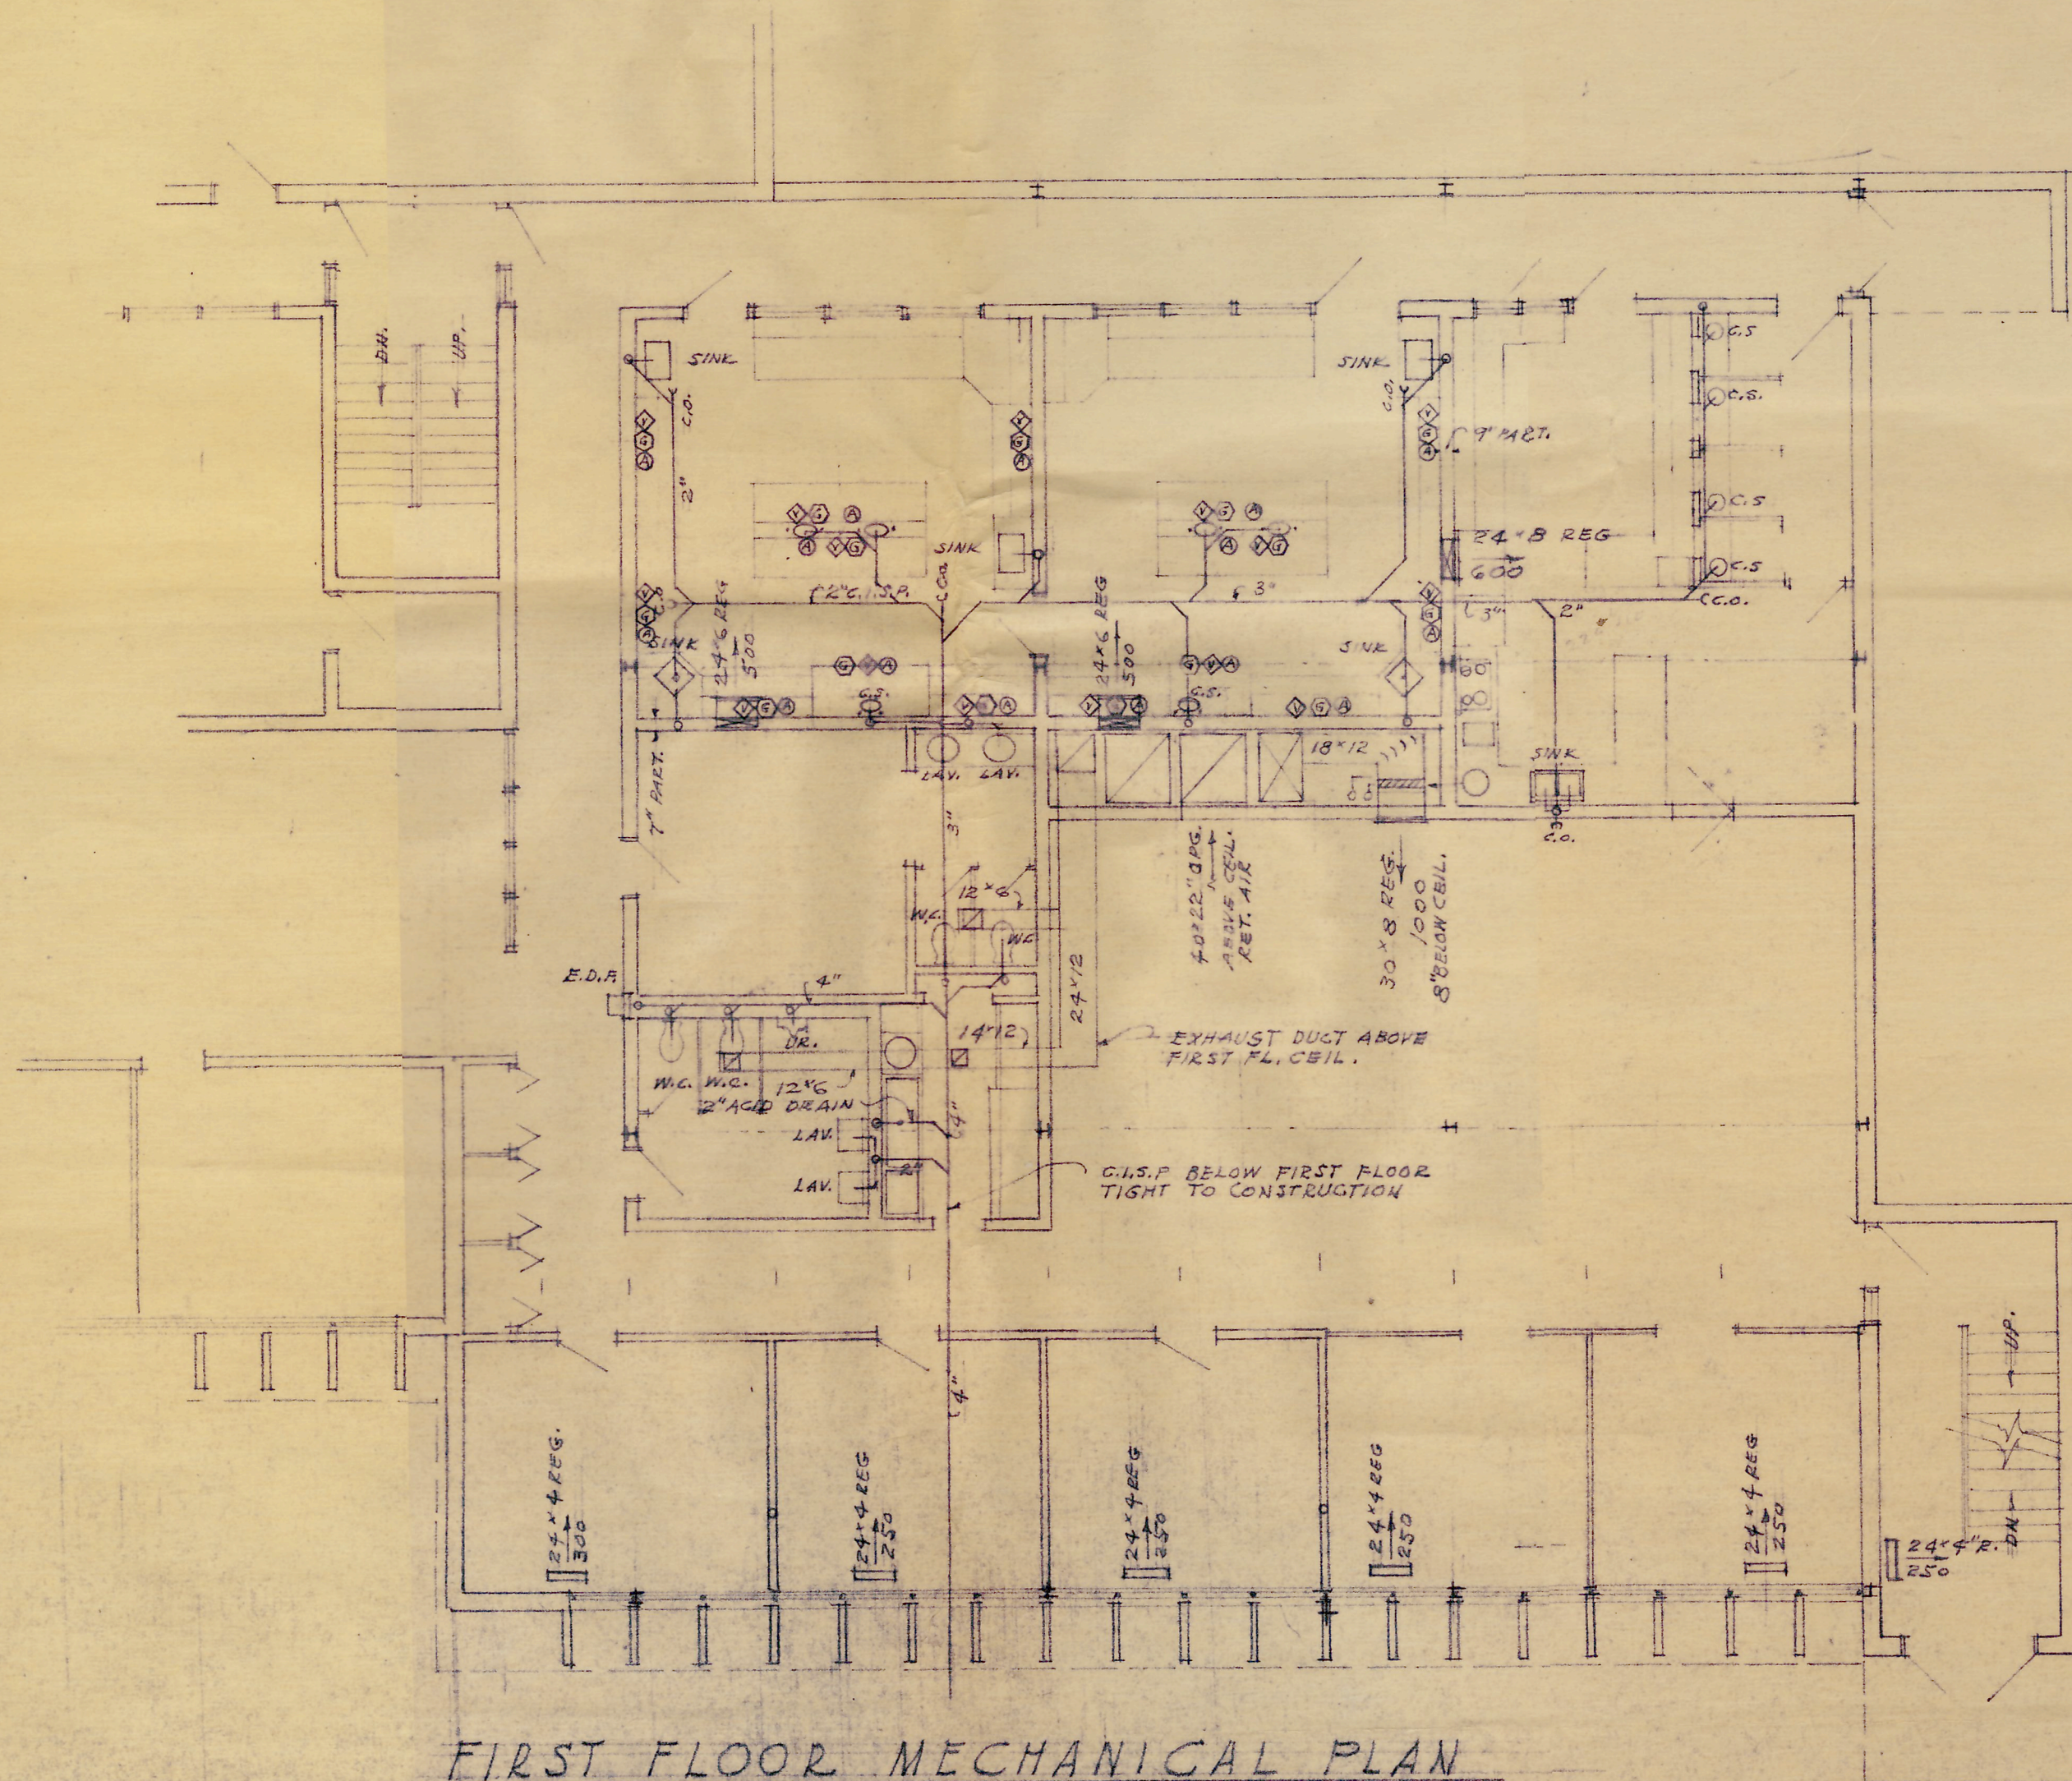

A

B

C


D

E

F

G

Н

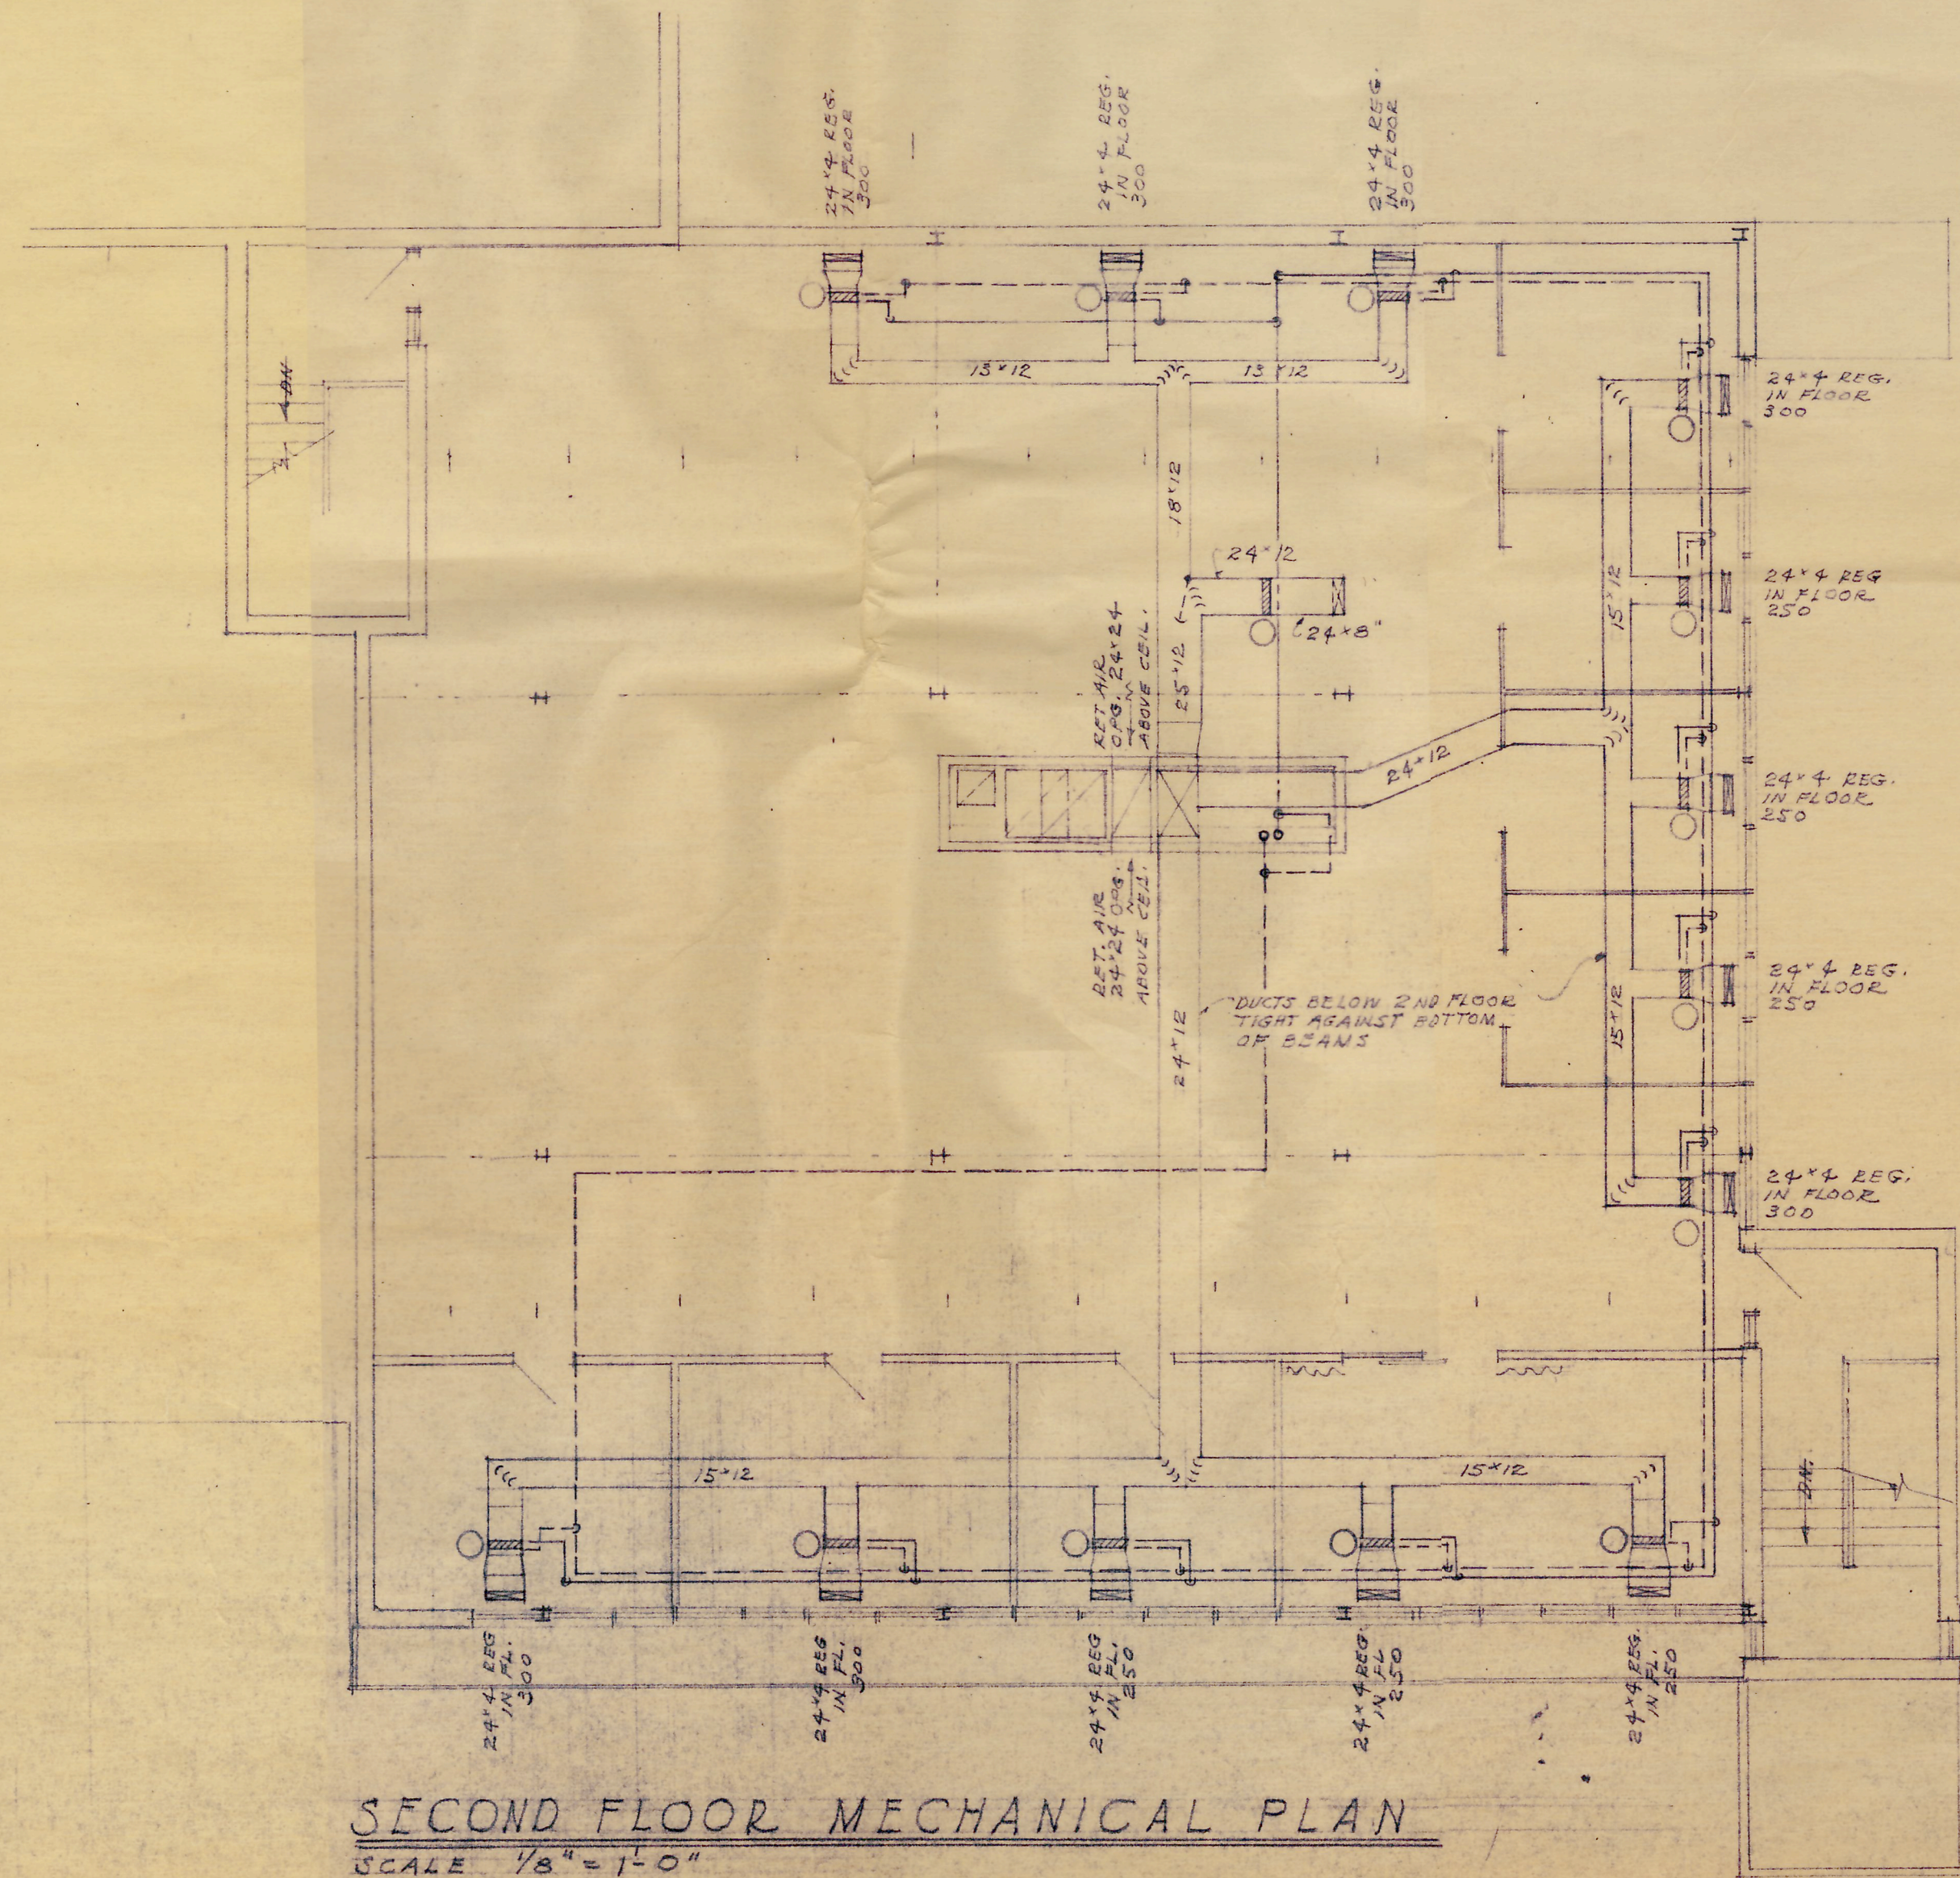

SECOND FLOOR MECHANICAL PLAN

SCALE $\frac{1}{8}'' = 1'-0''$

C O M M .

DATE

D R A W N

C H E C K E D

R E V I S E D

	OF

M-2

MILLER • HIETT • DRONBERGER • ARBUCKLE and
architects and engineering, construction, Kansas

A

B

C


D

E

F

G

H

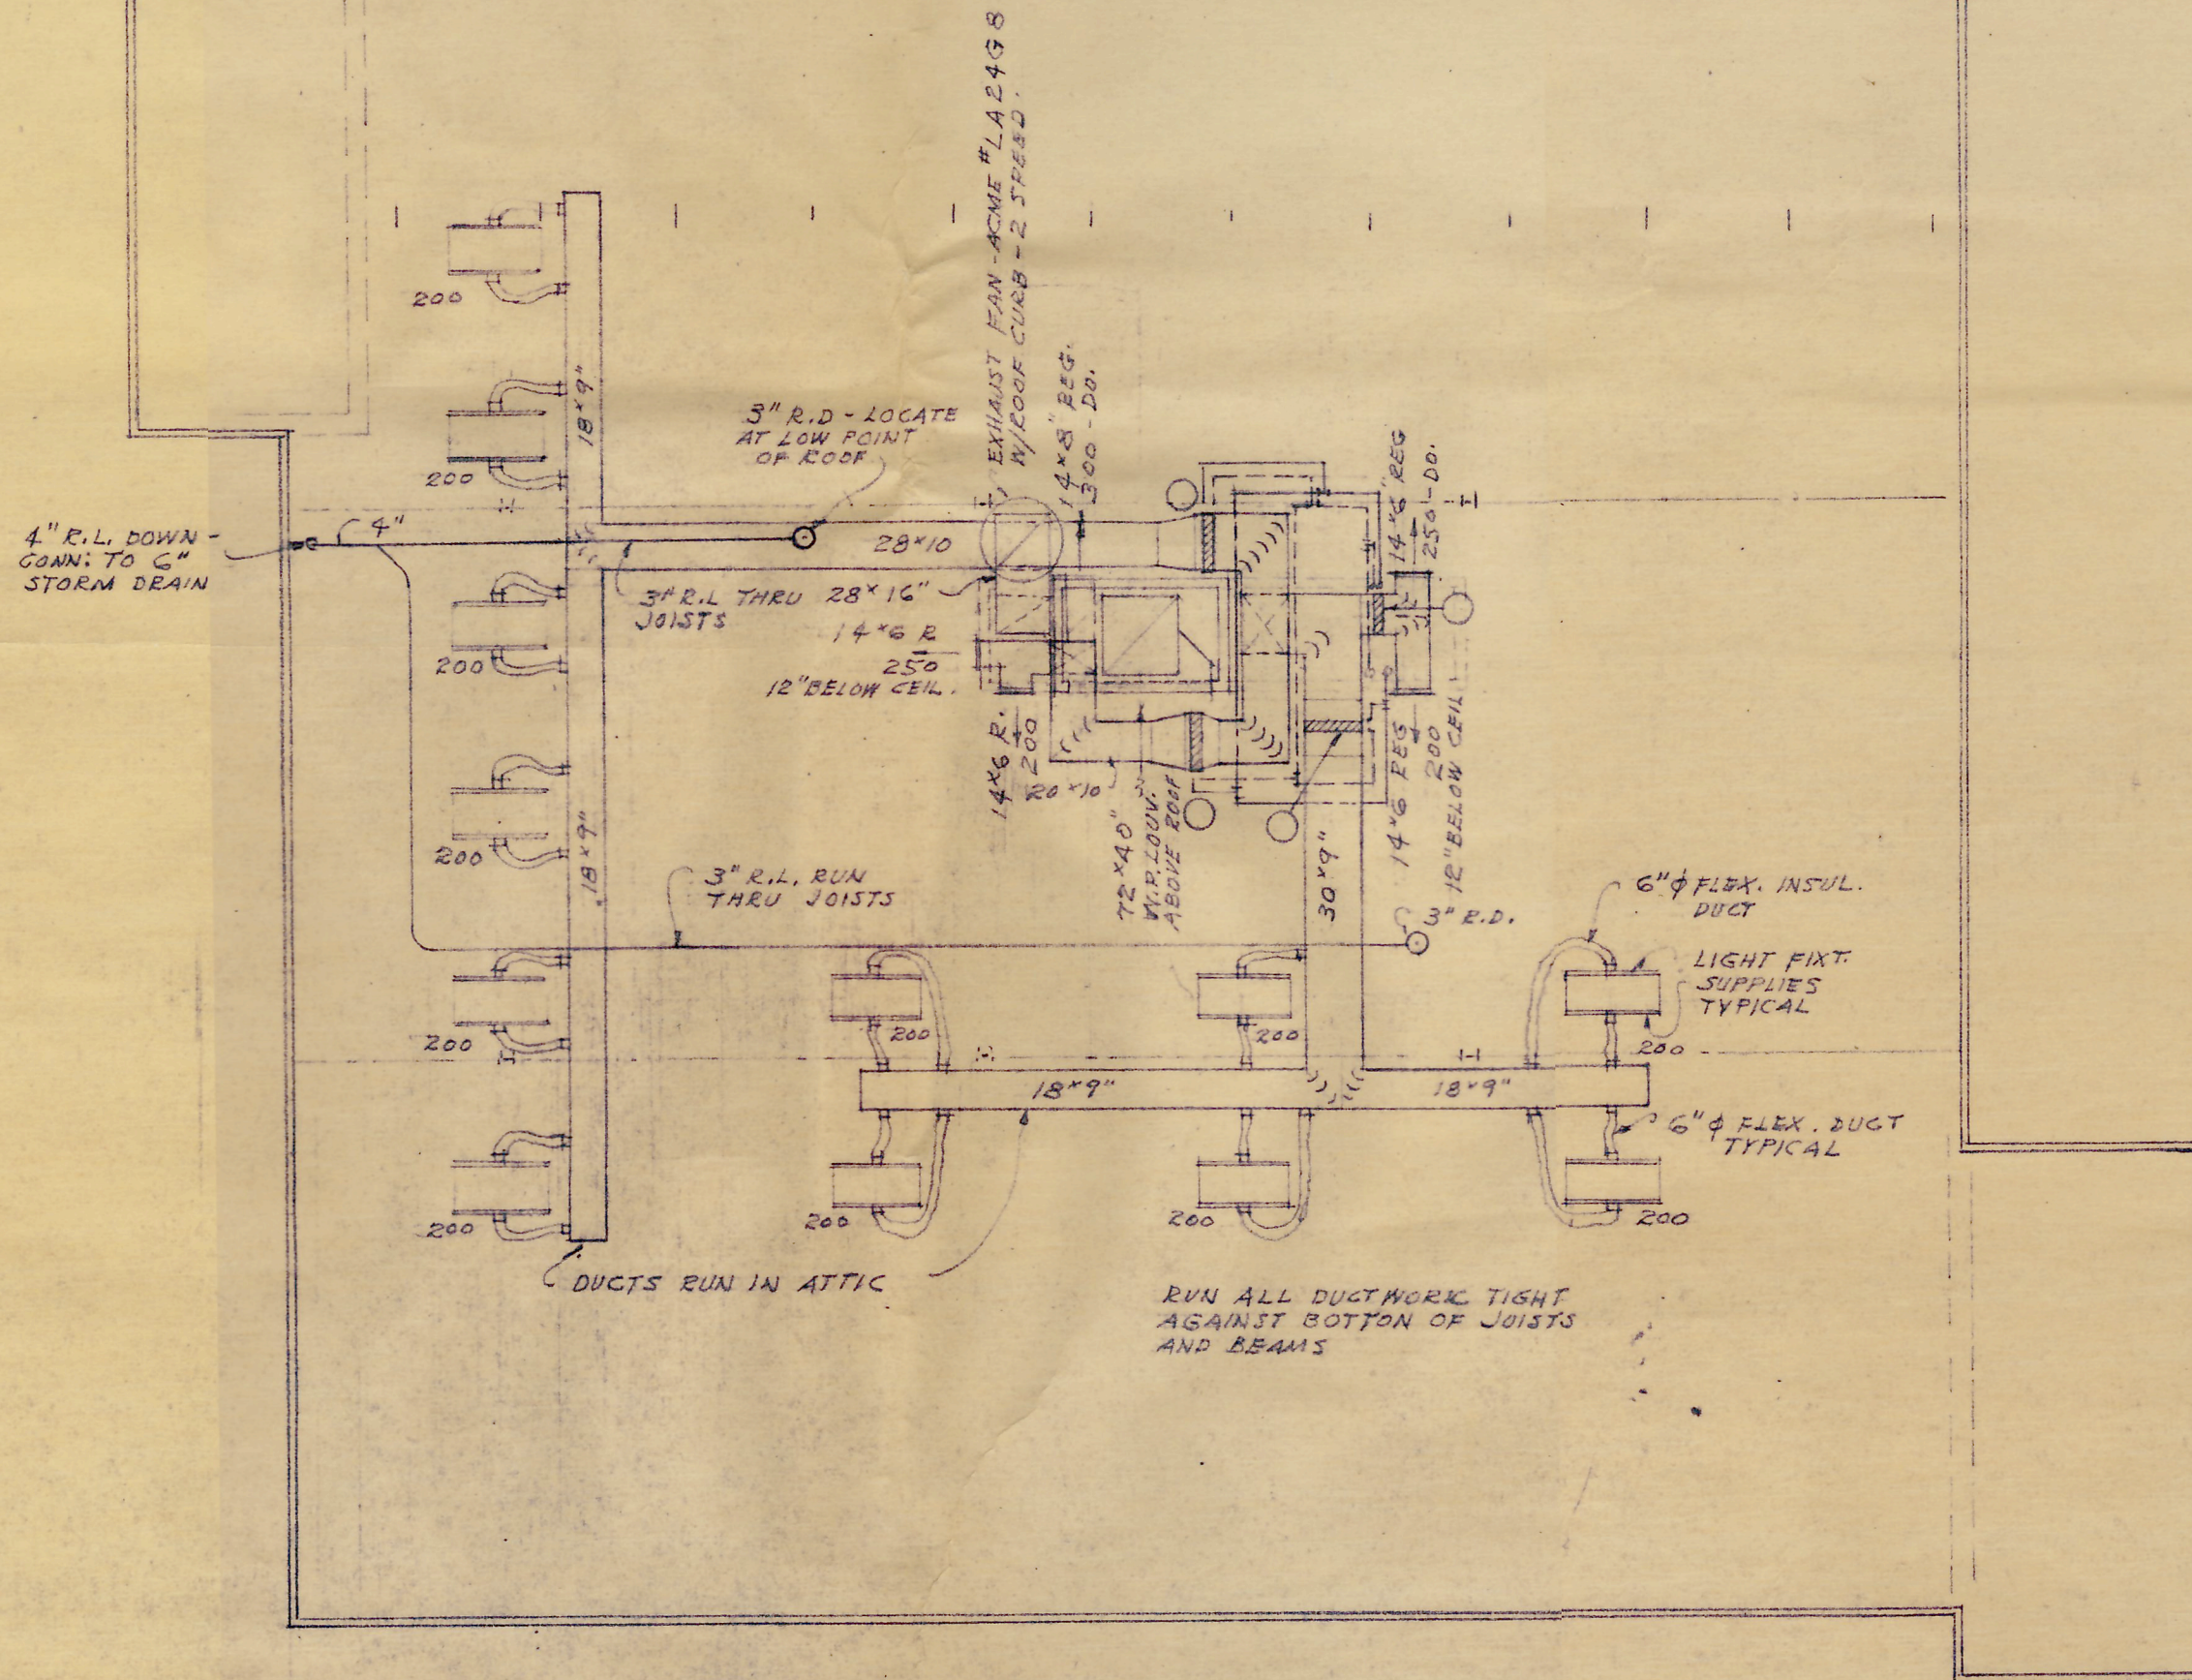

MECHANICAL ROOF PLAN

SCALE - 1/8" = 1'-0"

MILLER • HIETT • DRONBERGER • ARBUCKLE and WALKER
architects and engineers hutchinson, kansas

OF

COMM.

 
 
 
 
 
 
 
 
DATE

DRAWN

CHECKED

REVISED

M-4



S-2	OF
	2